



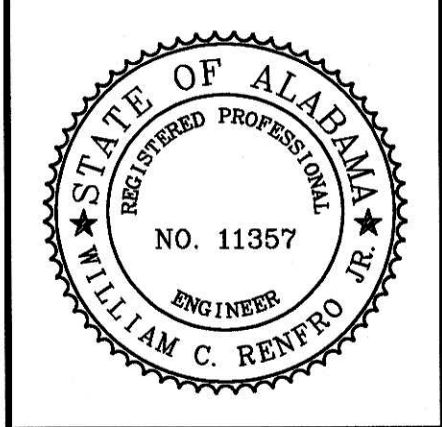

WATER WORKS & SEWER BOARD
CITY OF ANNISTON
CHOCOLOCO WWTP
IMPROVEMENTS
ANNISTON, ALABAMA

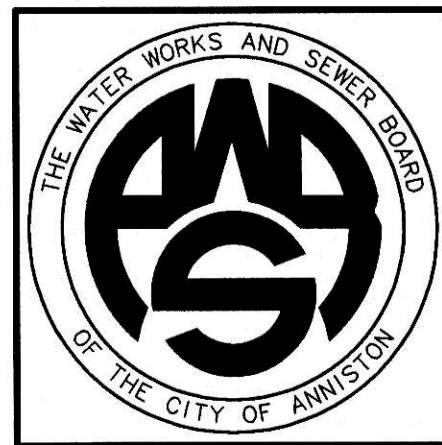


PROJECT NO. 98062		
DESIGNED	WCR	
DRAWN	CAB	
CHECKED	WCR	
APPROVED		
DATE	JULY 1999	
REVISIONS		
NO.	DATE	DESCRIPTION
1	11-17-06	RECORD DRAWING

**RECORD
DRAWING**


**MAINTENANCE AND
CHLORINE/SO2 BUILDING
ELECTRICAL PLANS**

SHEET NO.
E8.01
SEQUENCE 84 OF 84

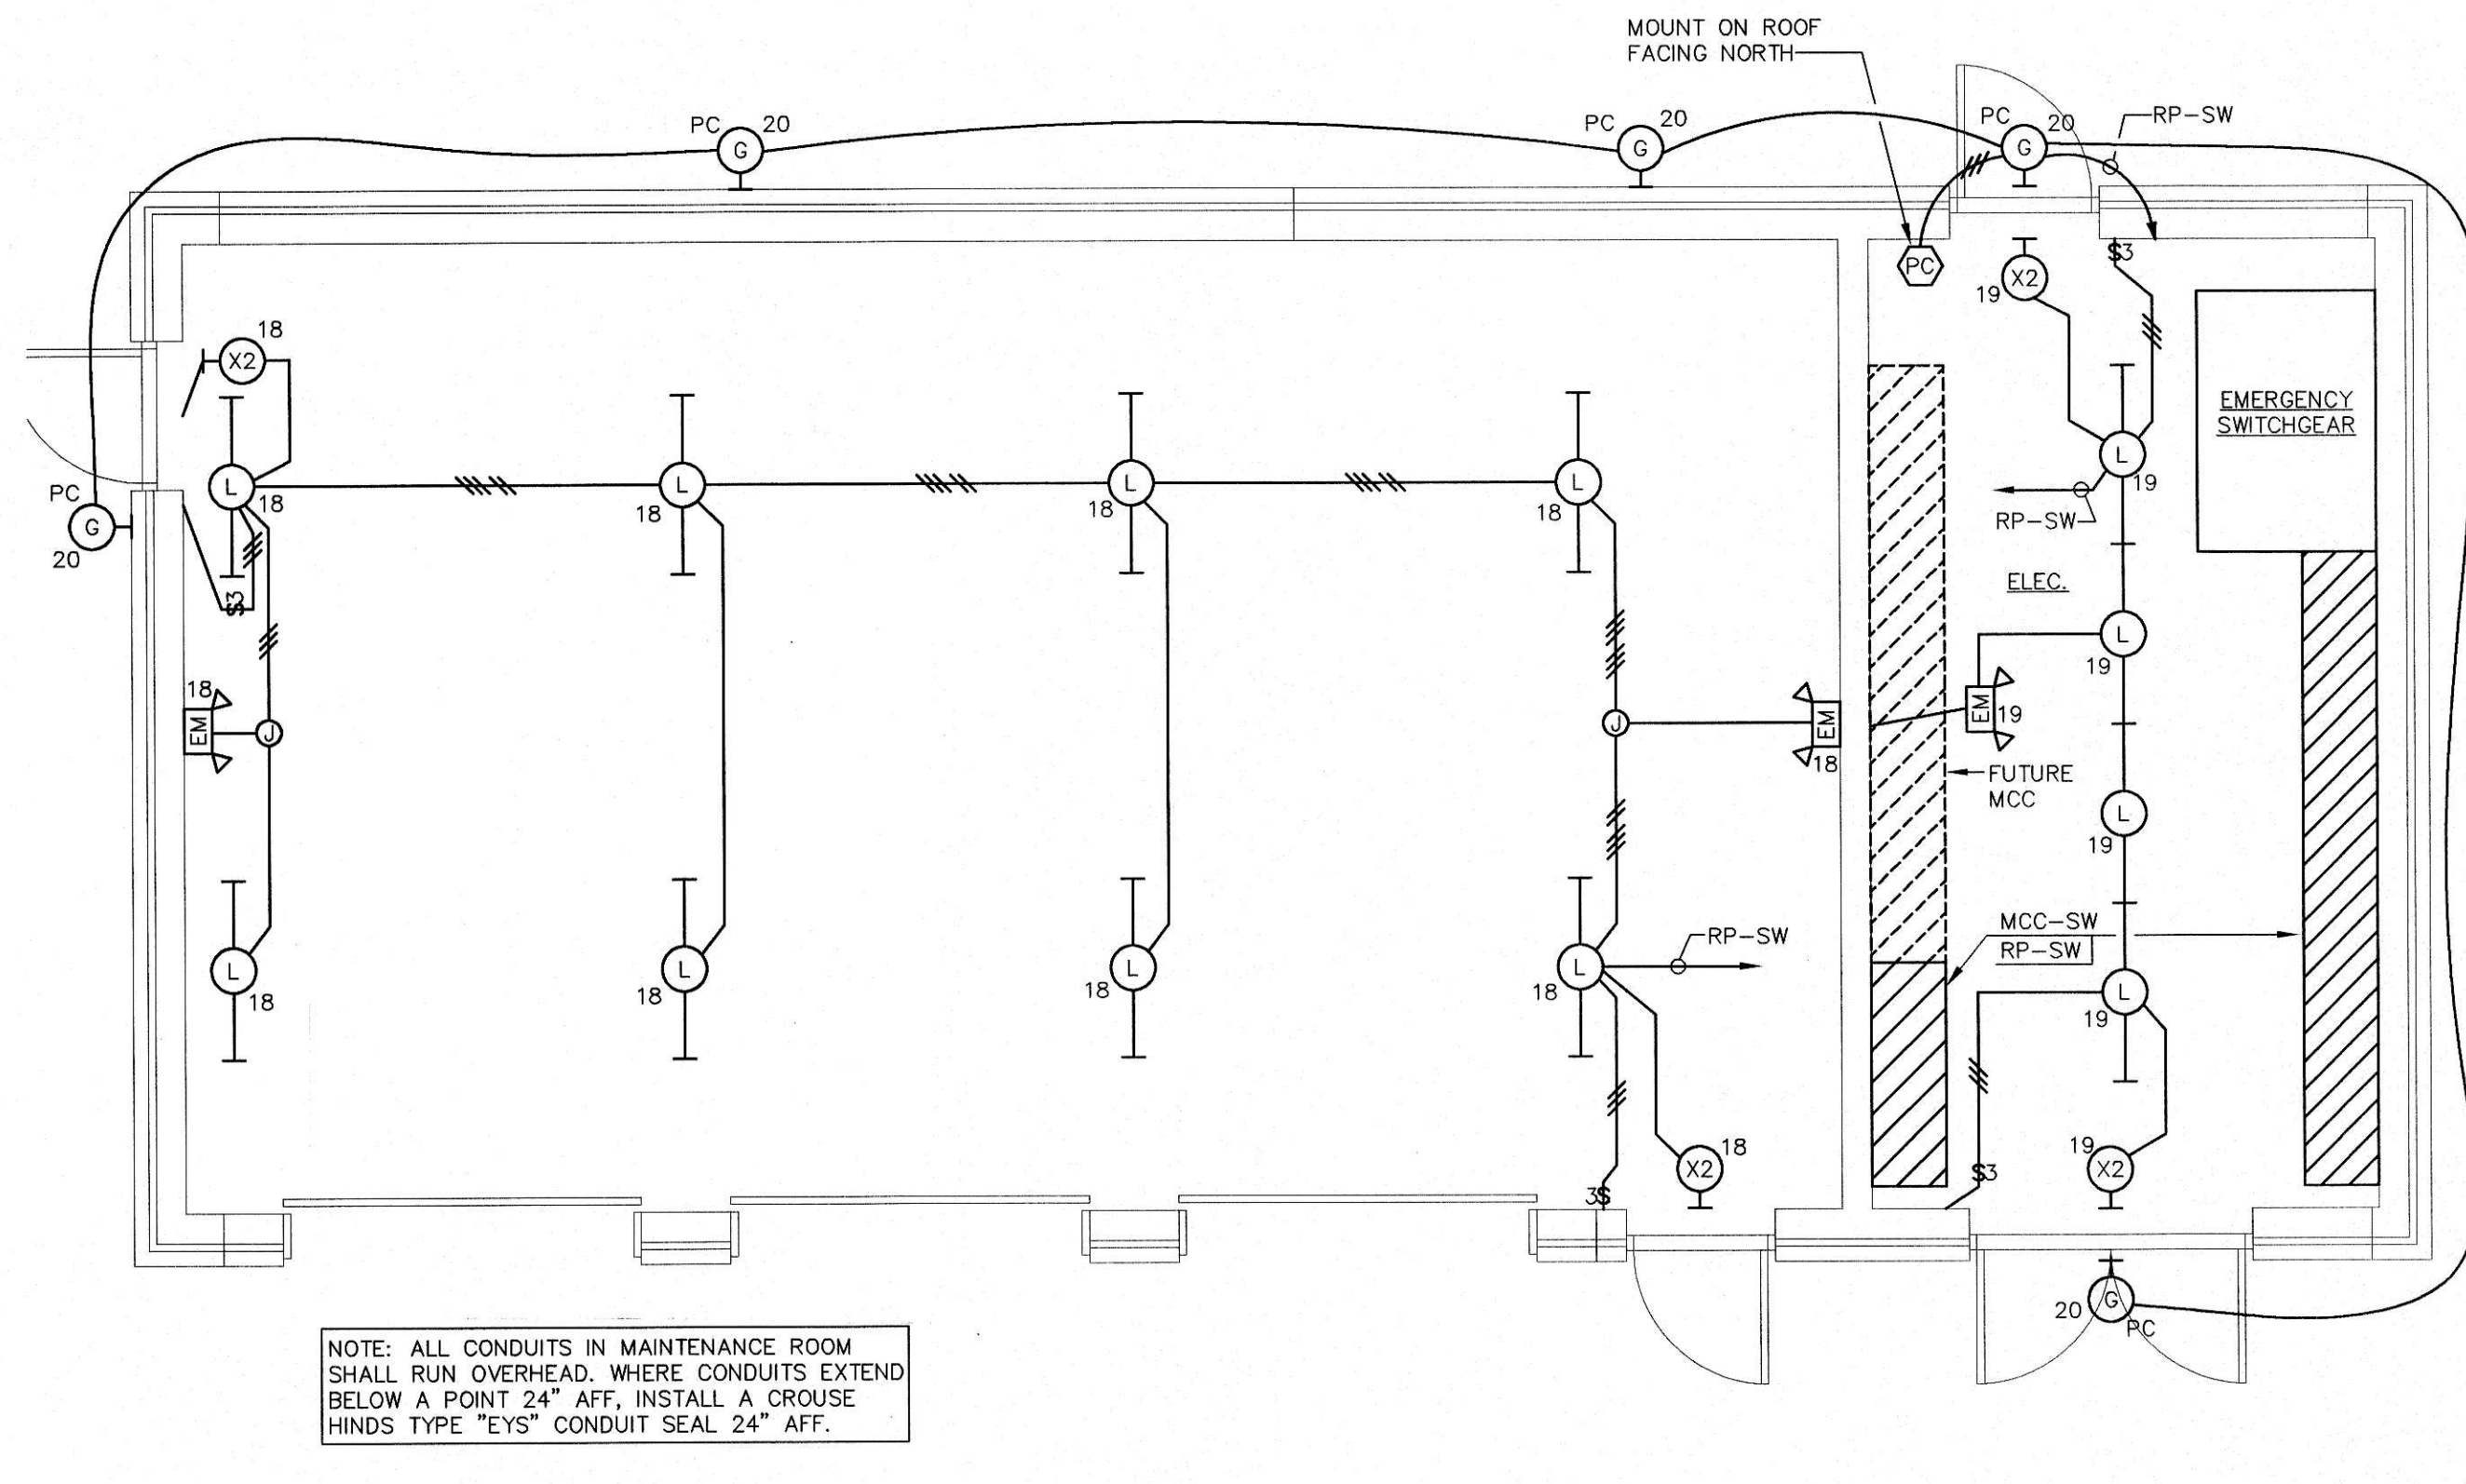


15 MAINTENANCE BUILDING LIGHTING PLAN

SCALE : 1/4" = 1'-0"

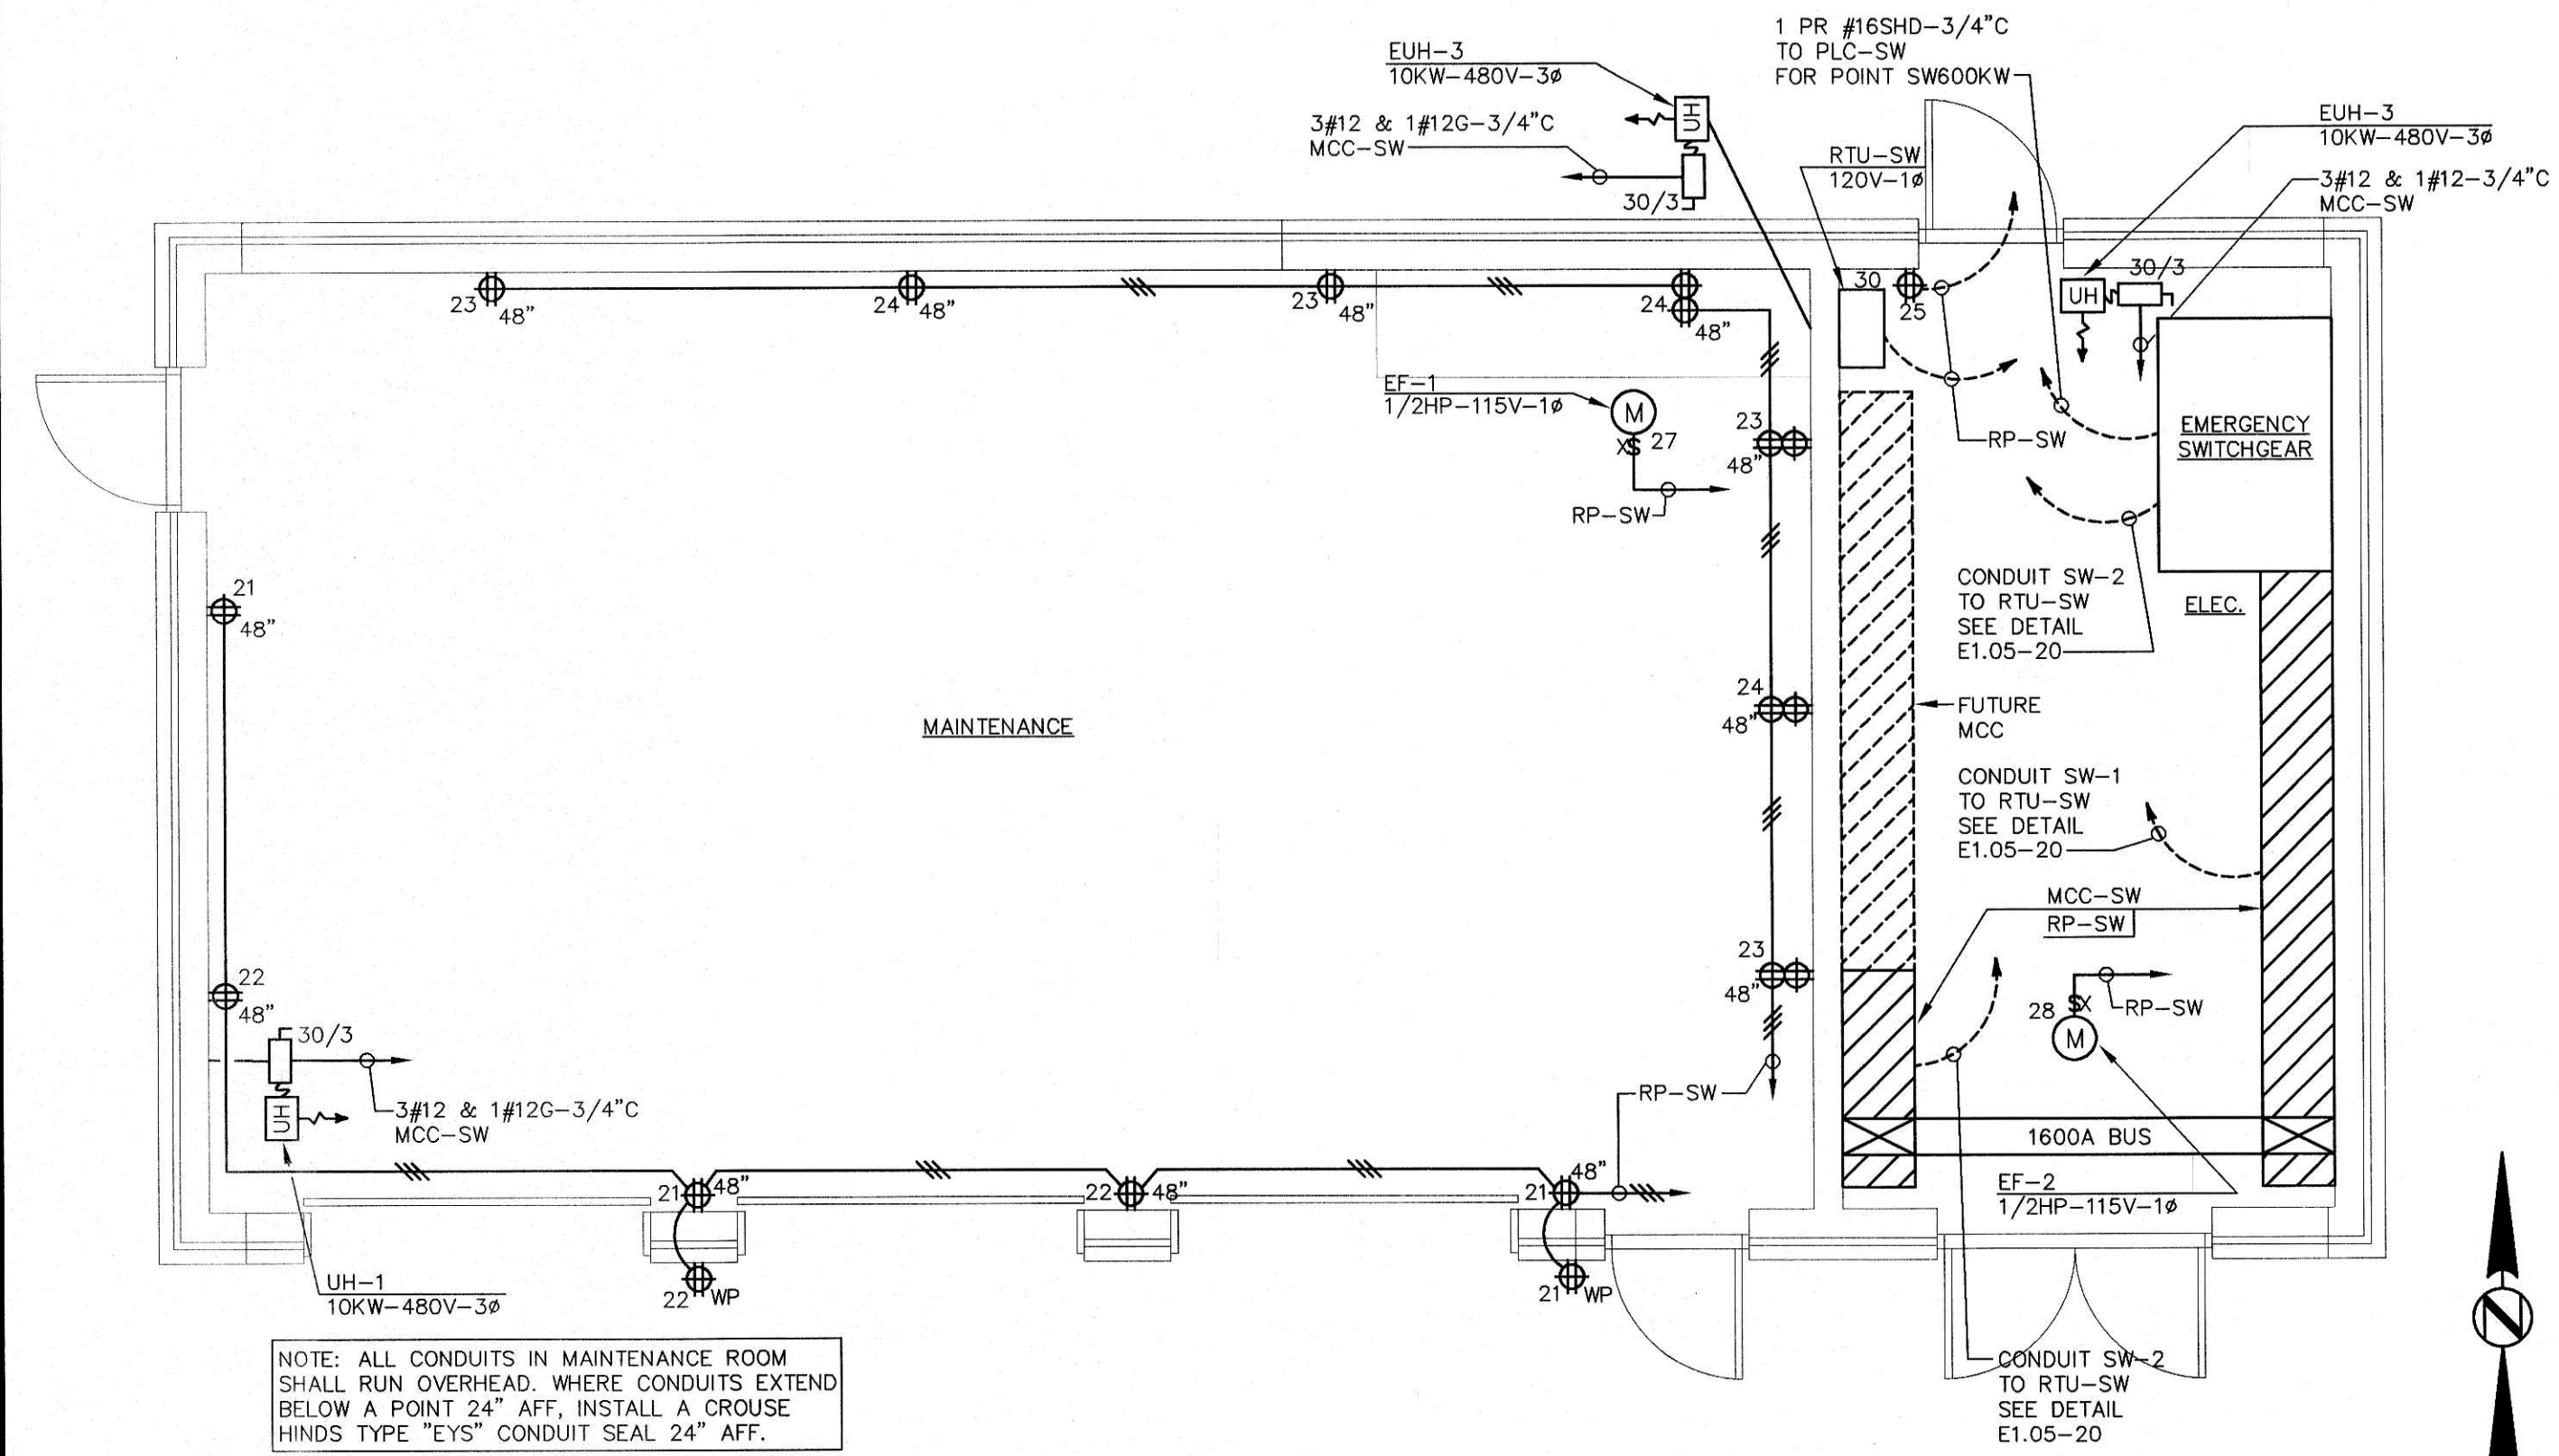

13 MAINTENANCE BUILDING POWER PLAN

SCALE : 1/4" = 1'-0"

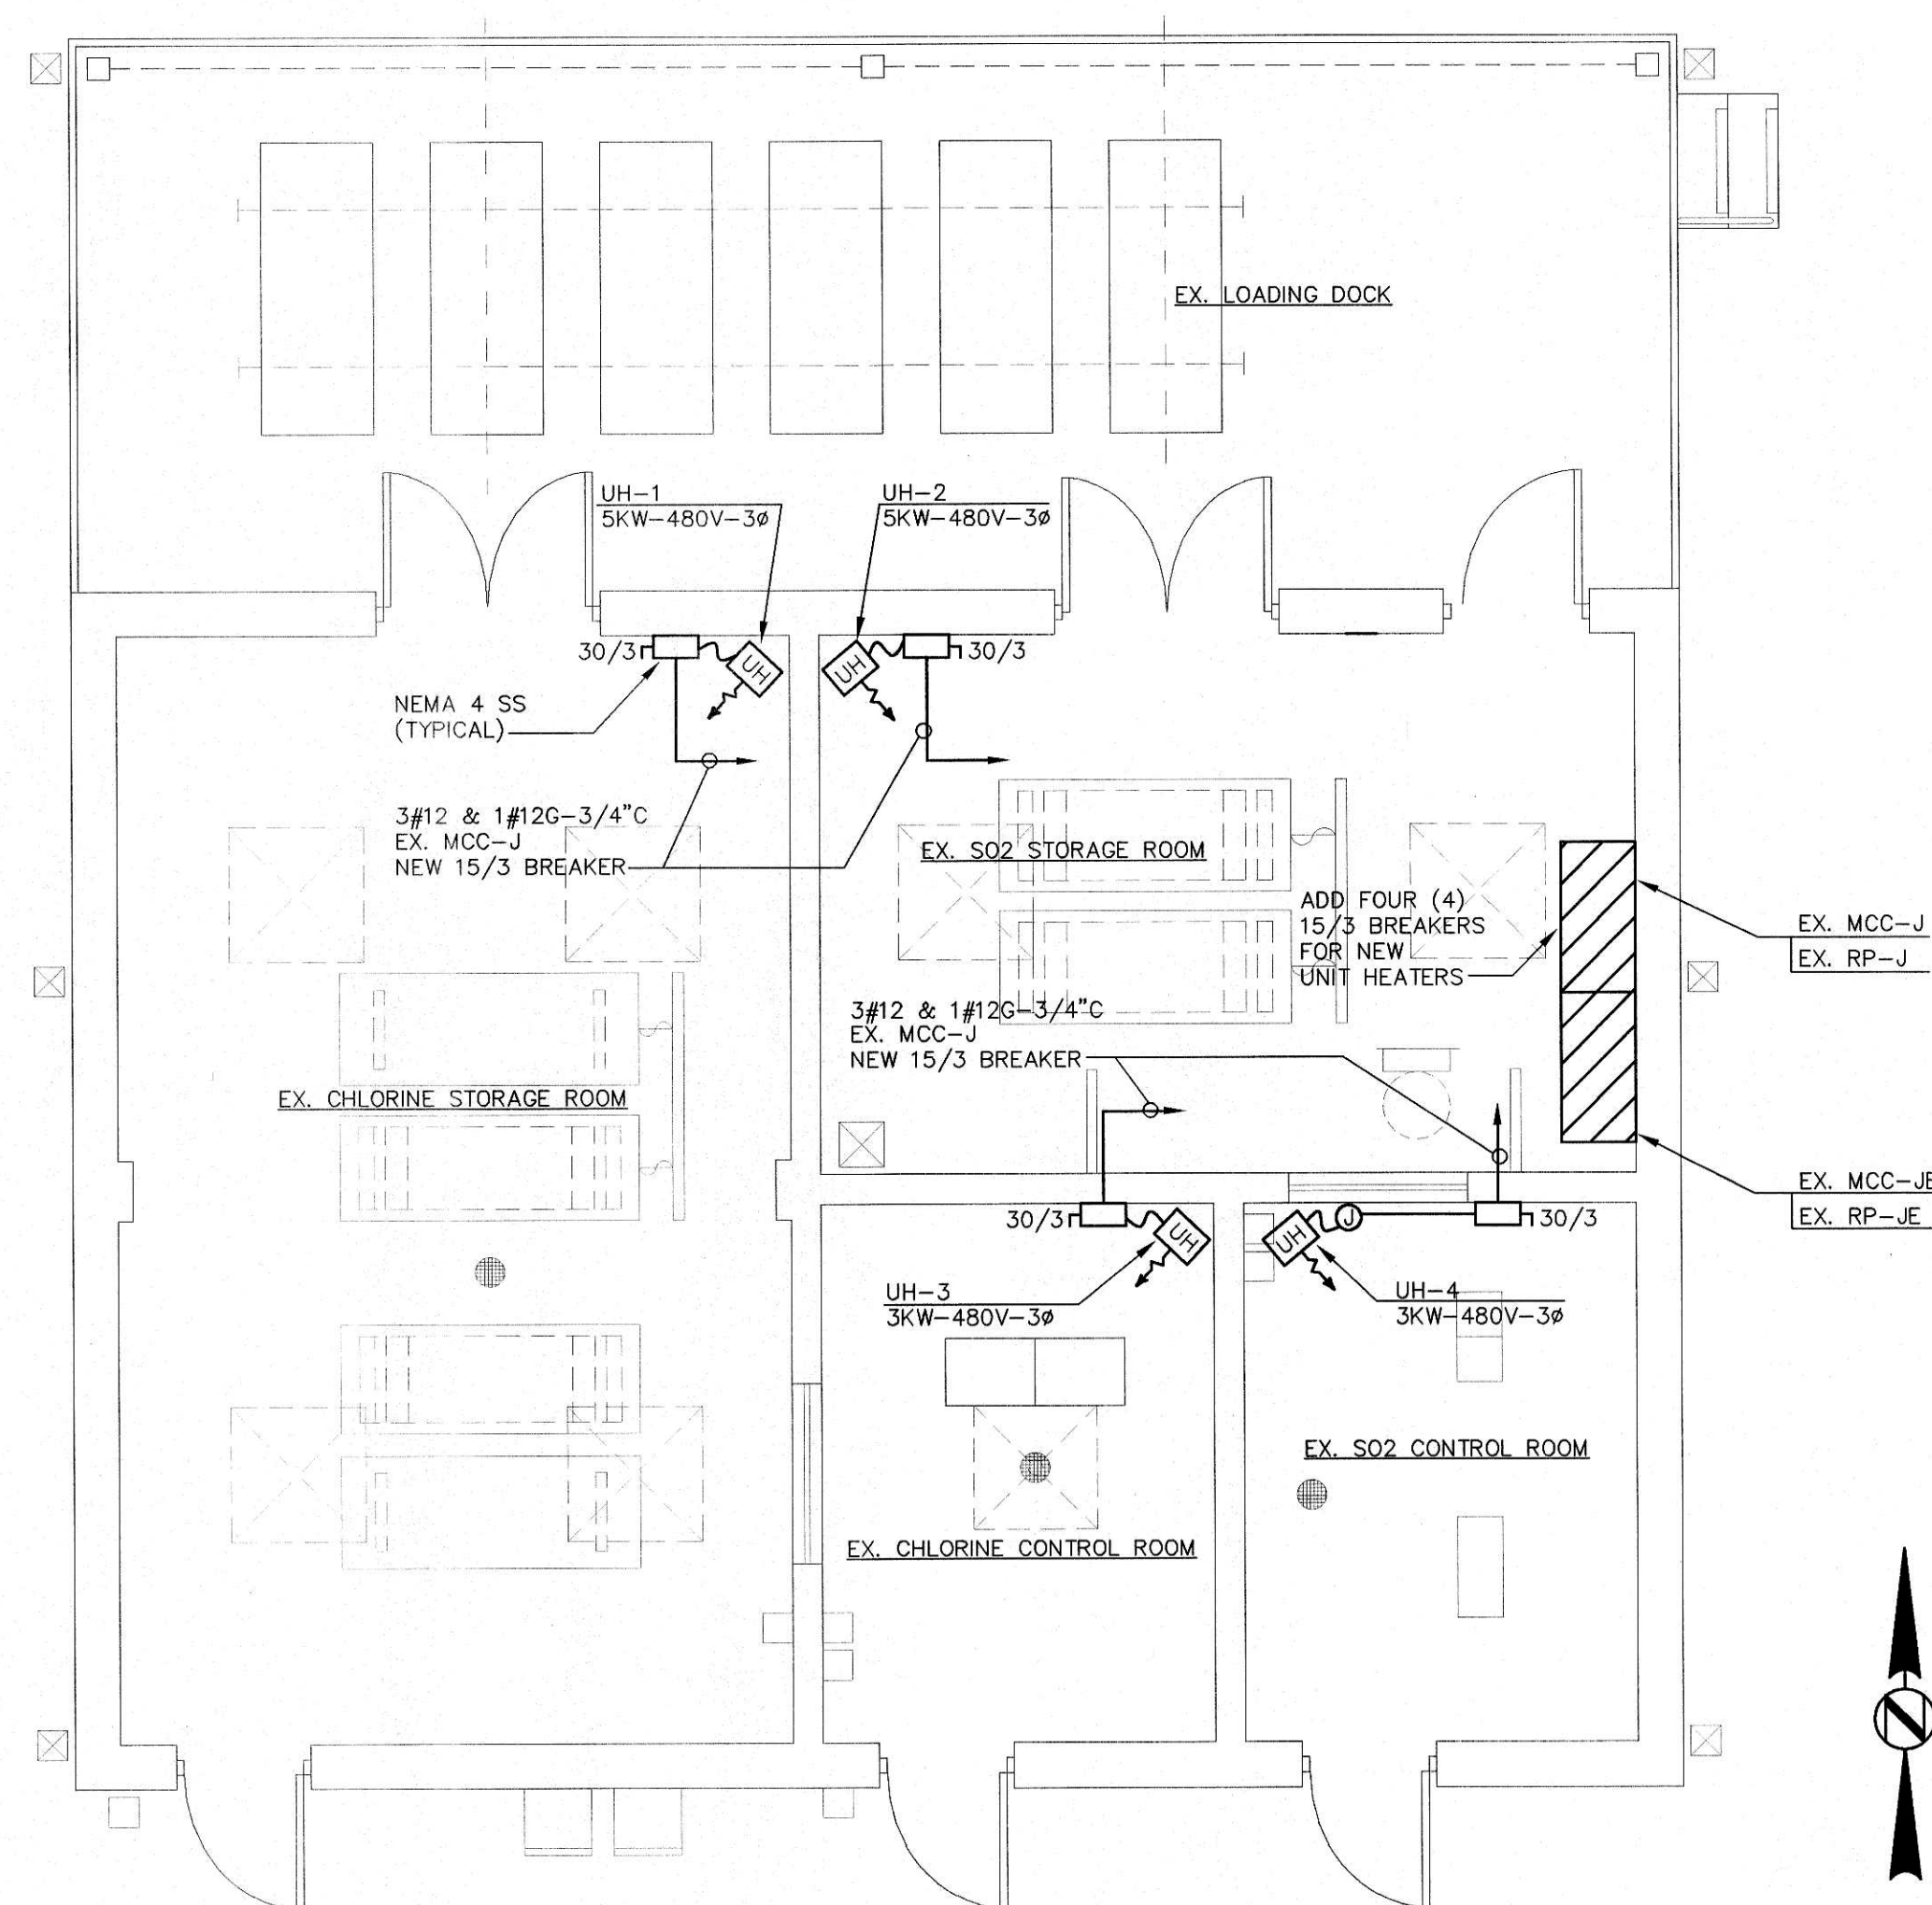


03 CHLORINE/SO2 BUILDING ELECTRICAL PLAN

SCALE : 1/4" = 1'-0"

05 ELECTRICAL ROOM-ALTERNATE ARRANGEMENT

SCALE : 1/4" = 1'-0"

JACKSON, RENFRO & ASSOC., INC.
141 VILLAGE STREET • SUITE 1
BIRMINGHAM, ALABAMA 35242
JRA JOB NO. 99002

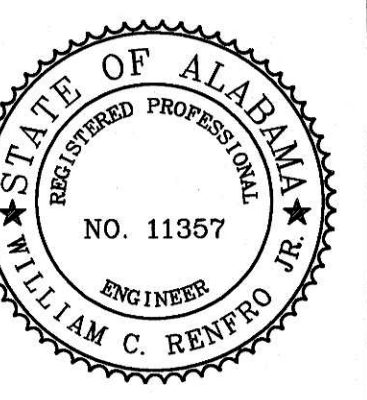

WATER WORKS & SEWER BOARD
CITY OF ANNISTON
CHOCOCCO WWTP
IMPROVEMENTS
ANNISTON, ALABAMA




PROJECT NO. 98062		
DESIGNED	WCR	
DRAWN	CAB	
CHECKED	WCR	
APPROVED		
DATE	JULY 1999	
REVISIONS		
NO.	DATE	DESCRIPTION
1	11-17-06	RECORD DRAWING

RECORD
DRAWING

PEAK FLOW
PUMP STATION
ELECTRICAL PLAN

SHEET NO.
E6.02
SEQUENCE 83 OF 84

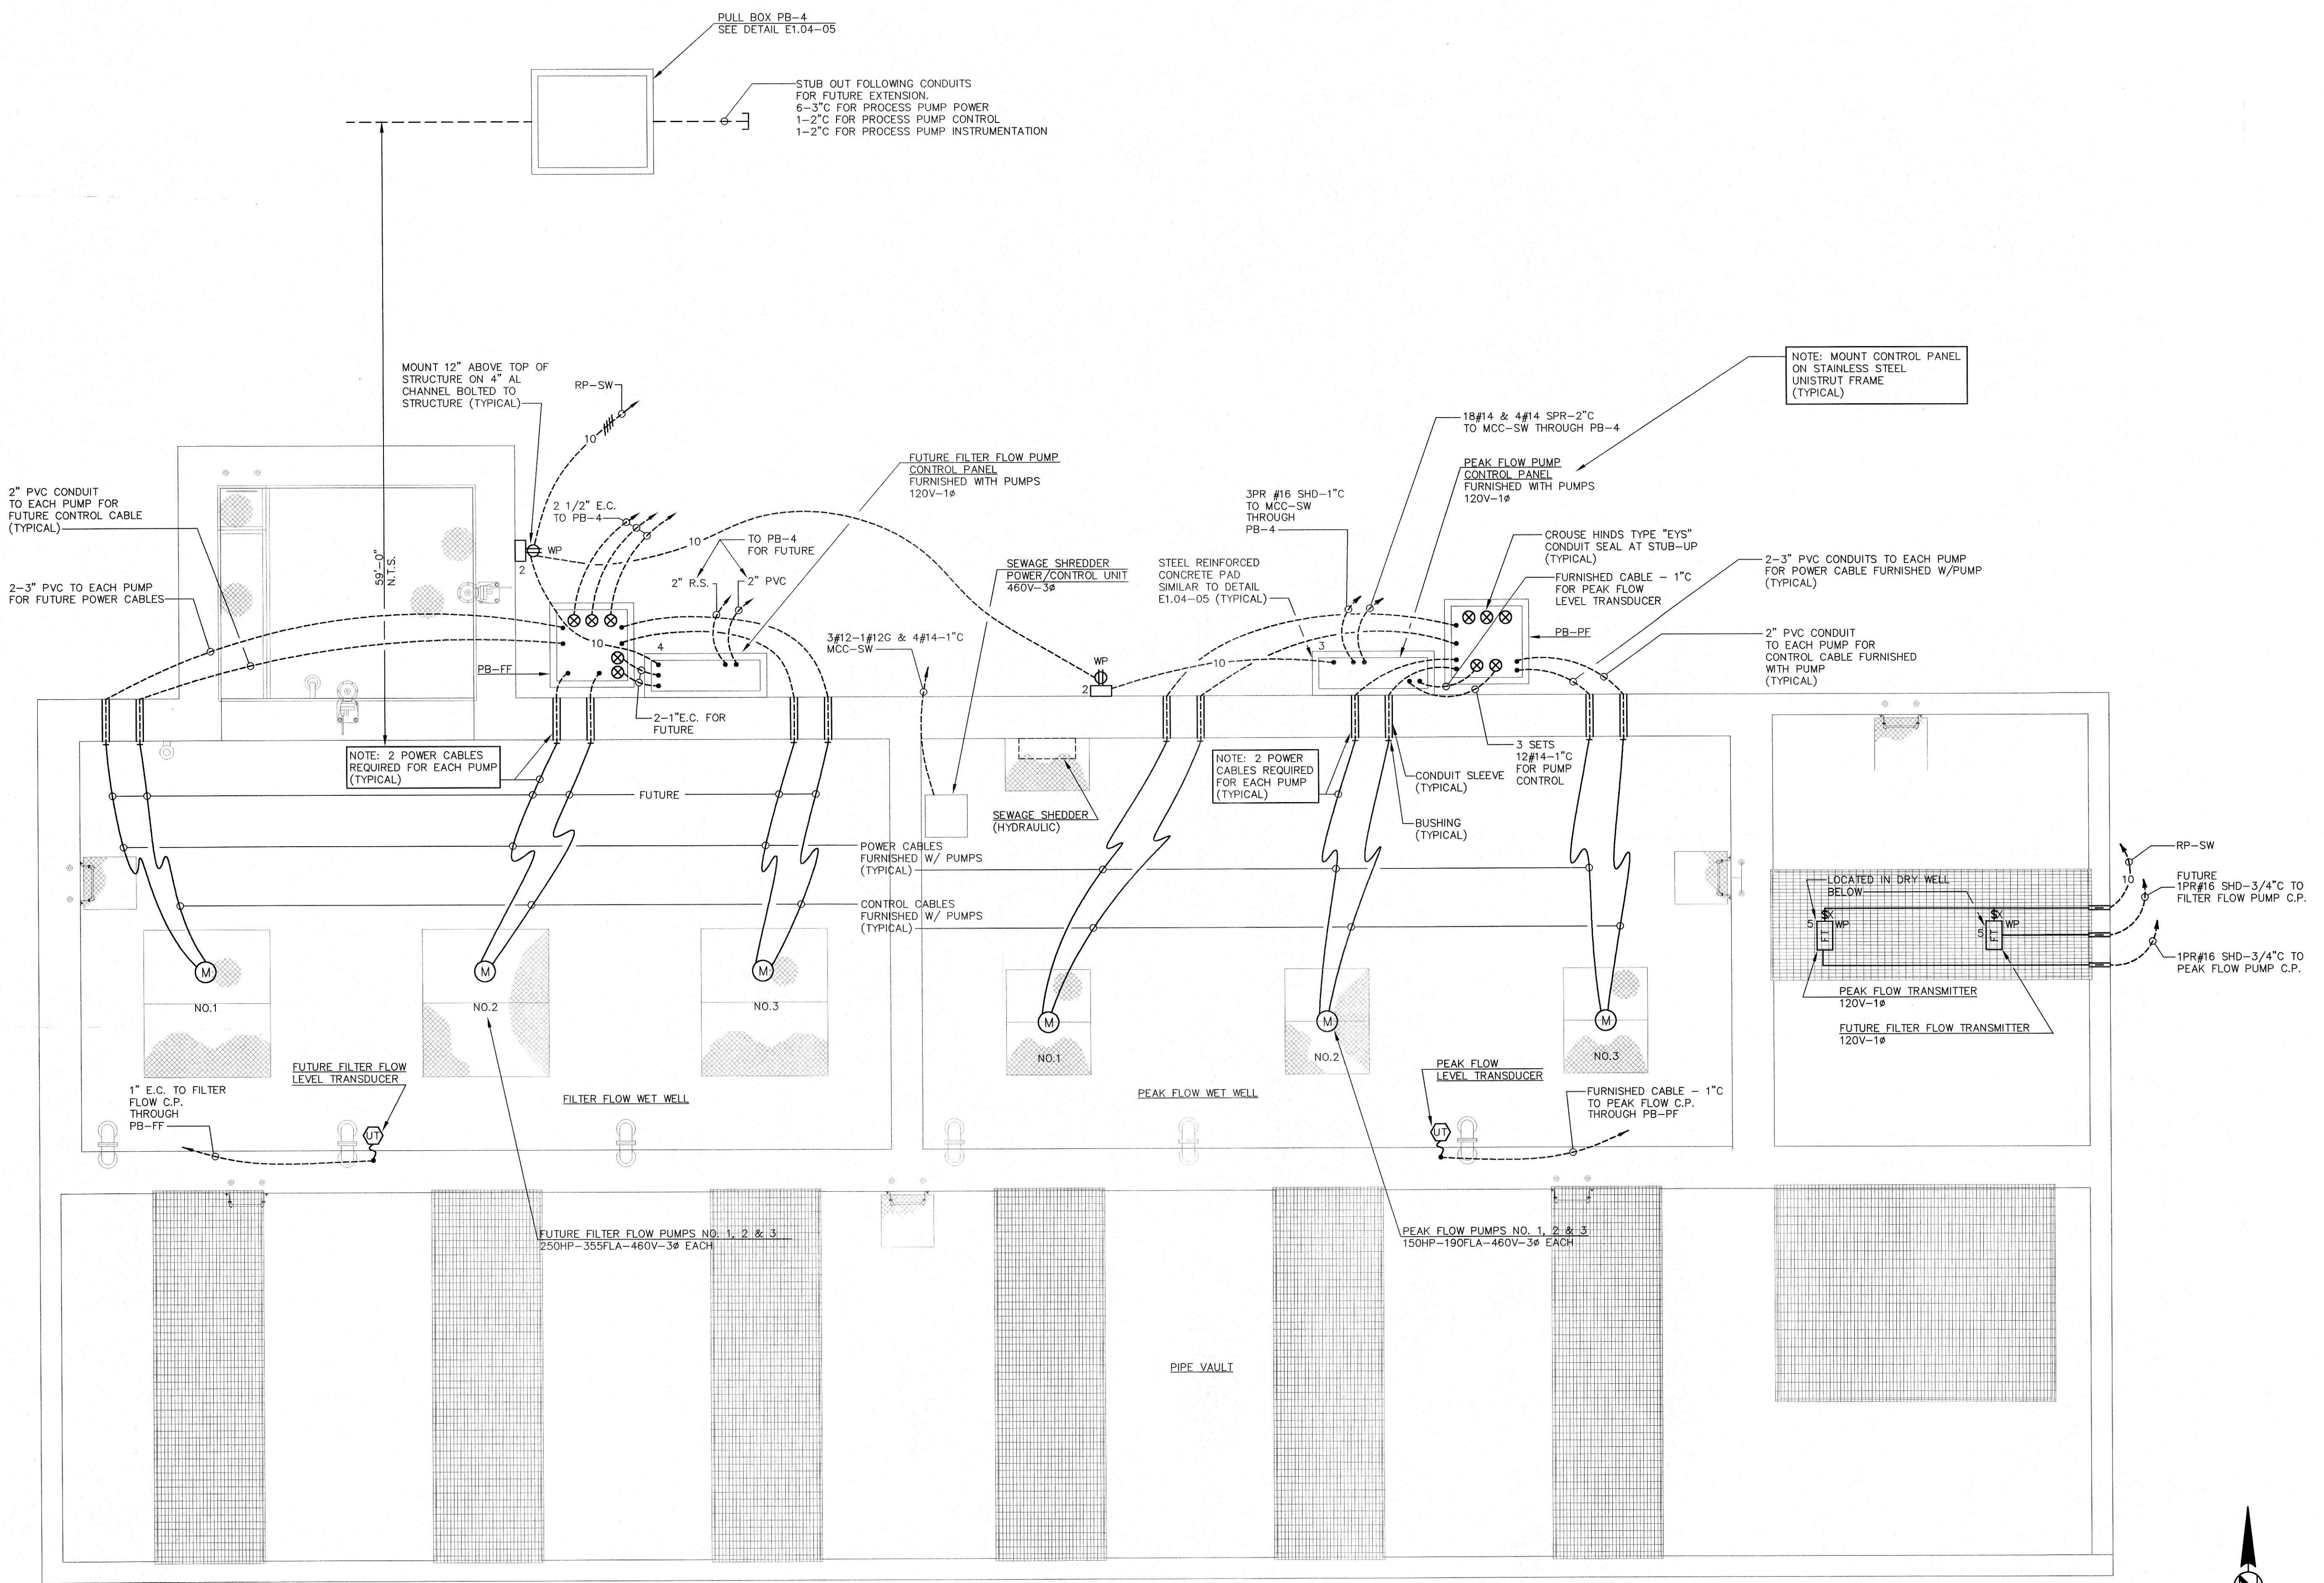

JACKSON, RENFRO & ASSOC., INC.
141 VILLAGE STREET • SUITE 1
BIRMINGHAM, ALABAMA 35242
JRA JOB NO. 99002

SCALE: 1/4" = 1'-0"

WATER WORKS & SEWER BOARD
CITY OF ANNISTON
CHOCOLOCCO WWTP
IMPROVEMENTS
ANNISTON, ALABAMA




PROJECT NO.			98062
DESIGNED			WCR
DRAWN			CAB
CHECKED			WCR
APPROVED			
DATE			
JULY 1999			
REVISIONS			
NO.	DATE	DESCRIPTION	
1	11-17-06	RECORD DRAWING	

RECORD
DRAWING

WASHDOWN PUMP ELECTRICAL PLAN

16.01


SEQUENCE 82 OF 84

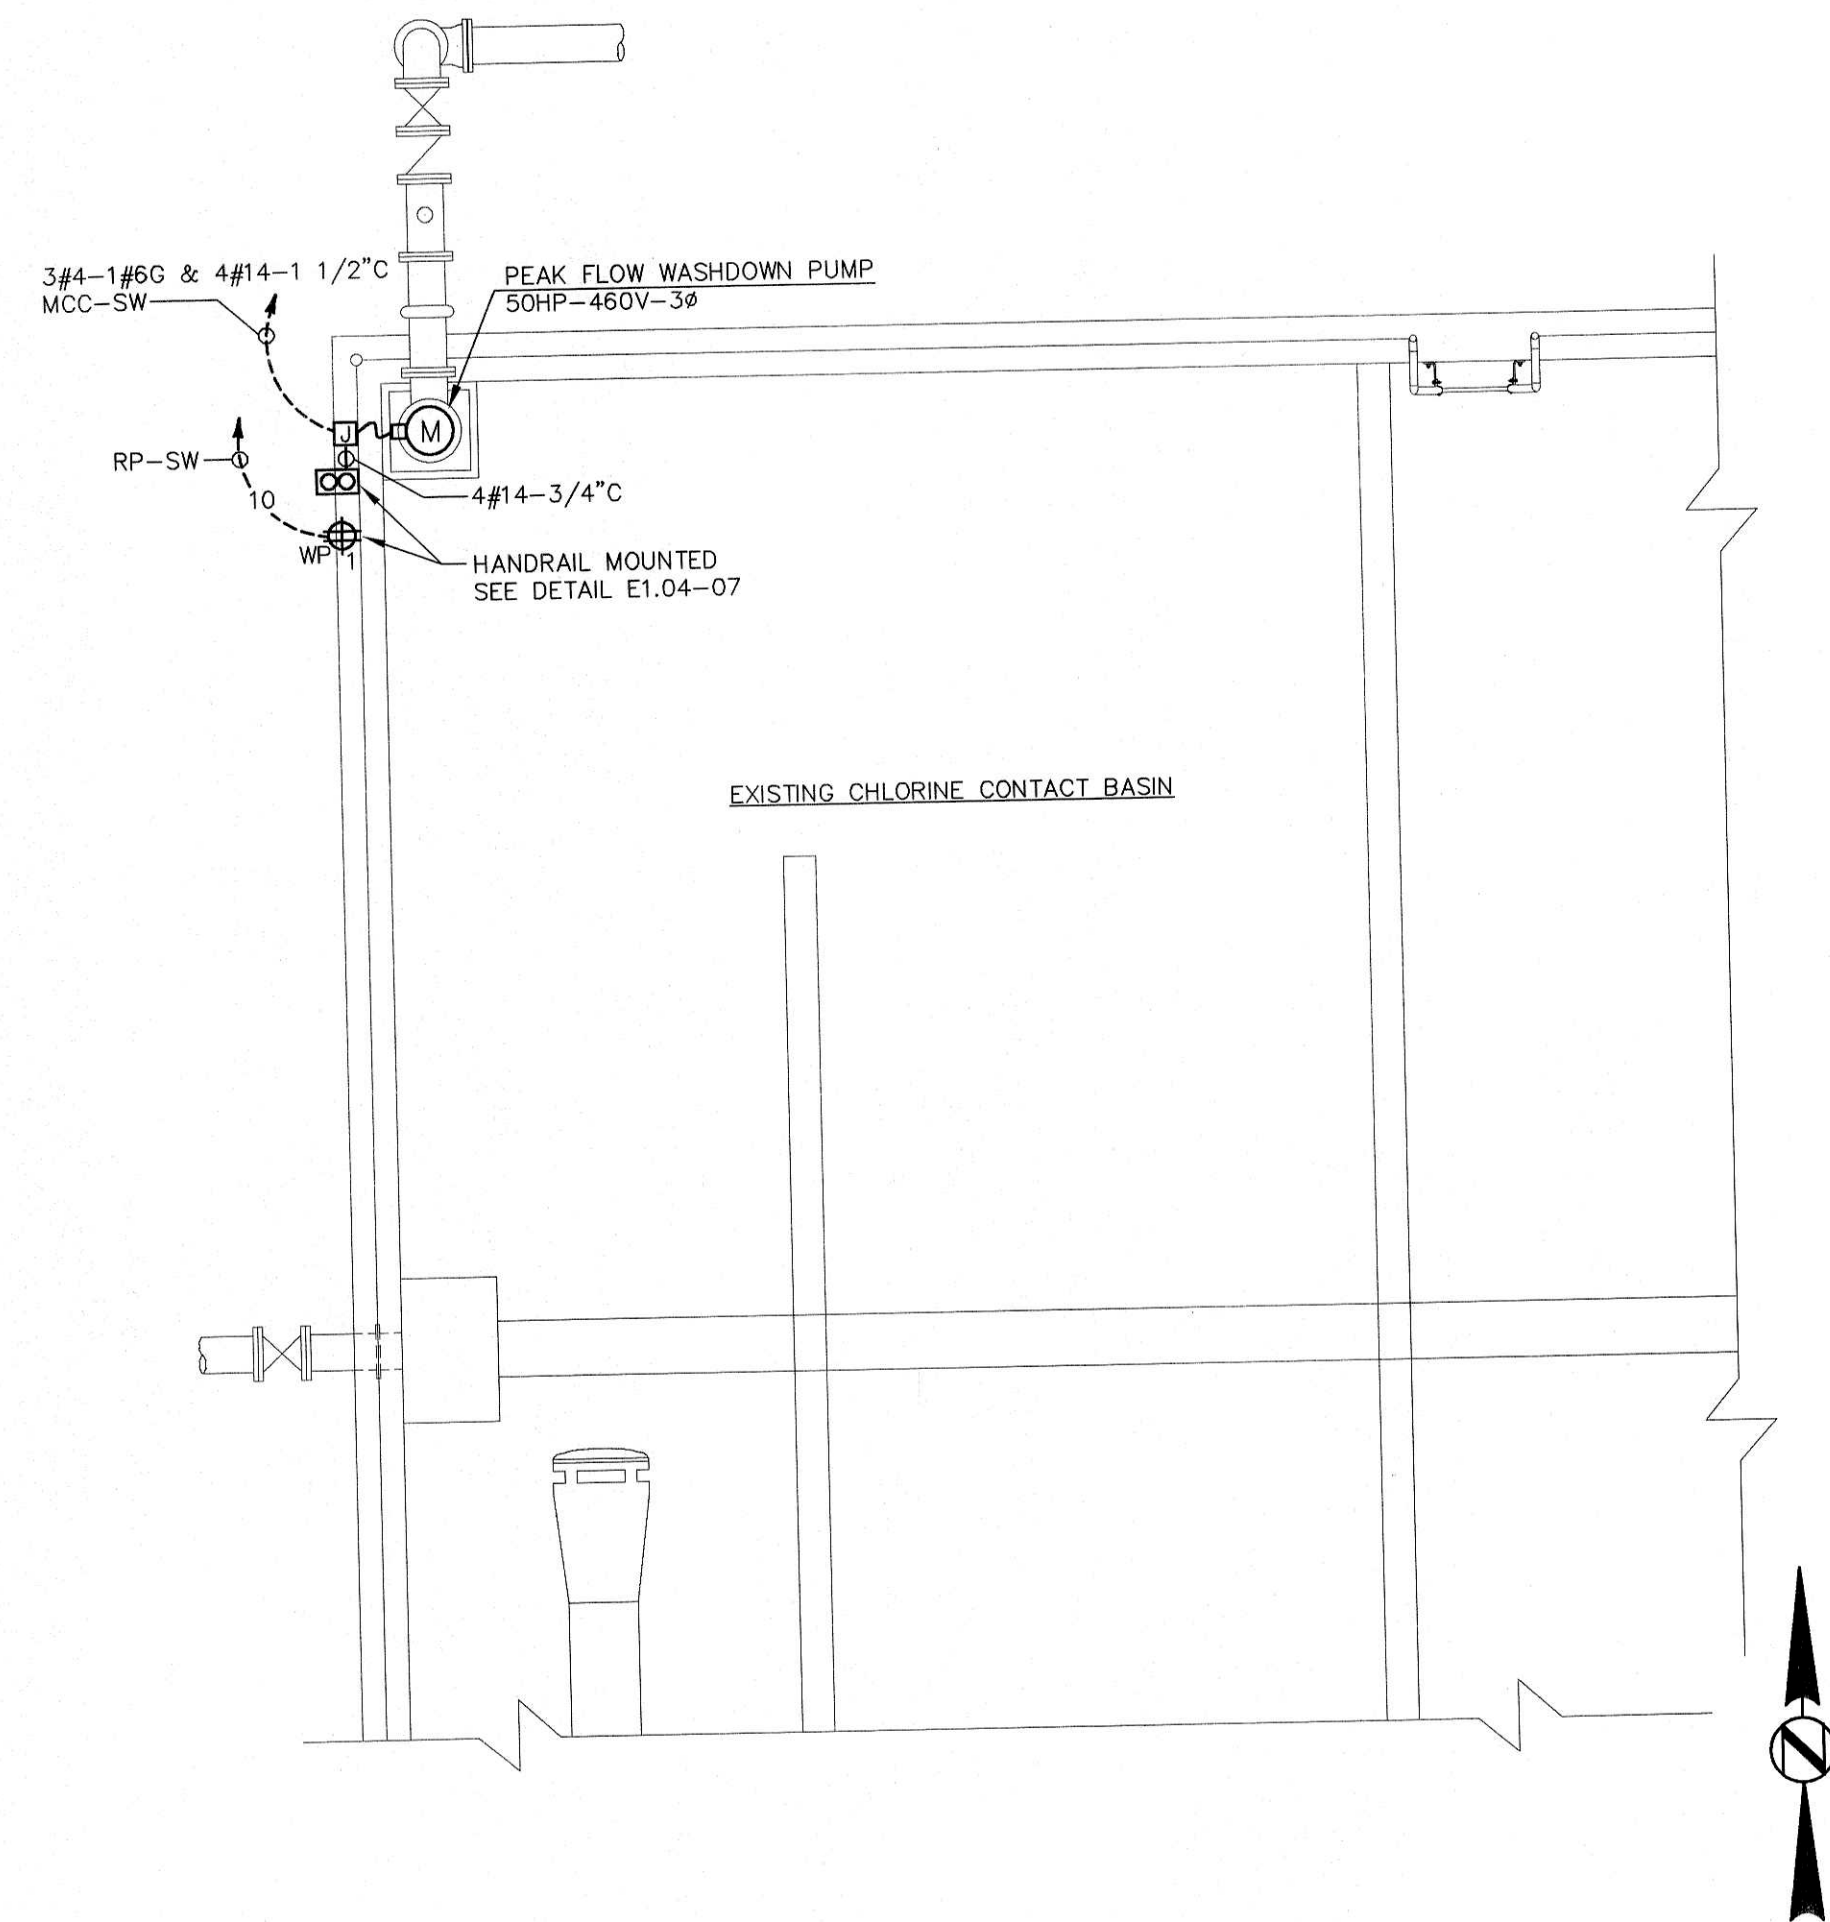


JACKSON, RENFRO & ASSOC., INC.
141 VILLAGE STREET • SUITE 1
BIRMINGHAM, ALABAMA 35242
JRA JOB NO. 99002

SCALE : 1/4" = 1'-0"

03	PEAK FLOW WASHDOWN PUMP ELECTRICAL PLAN
----	---

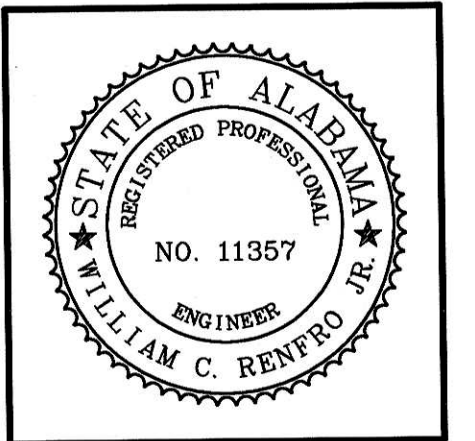

**WATER WORKS & SEWER BOARD
CITY OF ANNISTON
CHOCOLOCCO WWTP
IMPROVEMENTS
ANNISTON, ALABAMA**


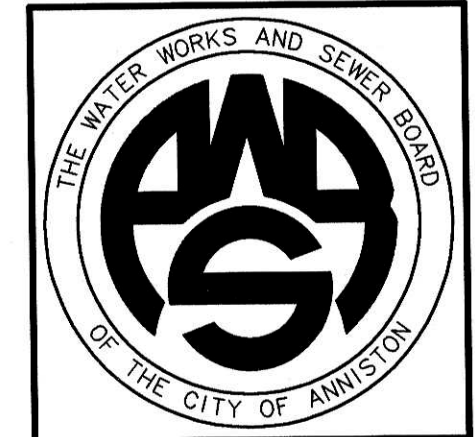


PROJECT NO.		
98062		
DESIGNED		
WCR		
DRAWN		
CAB		
CHECKED		
WCR		
APPROVED		
DATE		
JULY 1999		
REVISIONS		
NO.	DATE	DESCRIPTION
1	11-17-06	RECORD DRAWING

**RECORD
DRAWING**


**PEAK FLOW BASIN
ELECTRICAL PLAN
BASE BID**

E5.01
SEQUENCE 81 OF 84

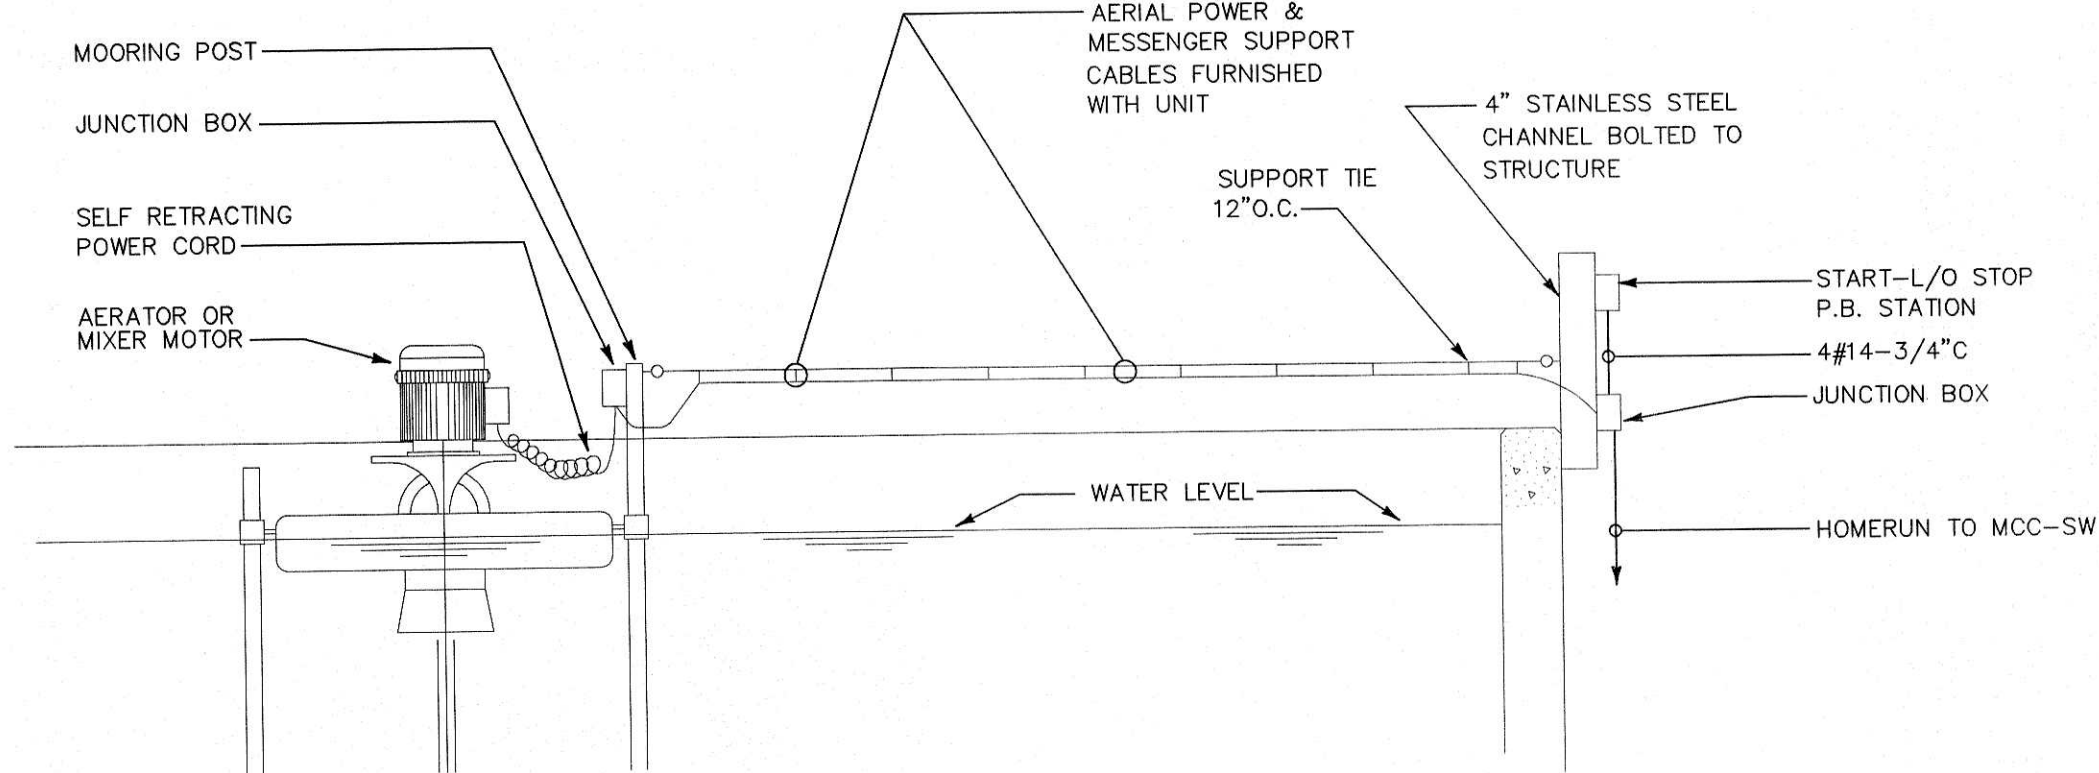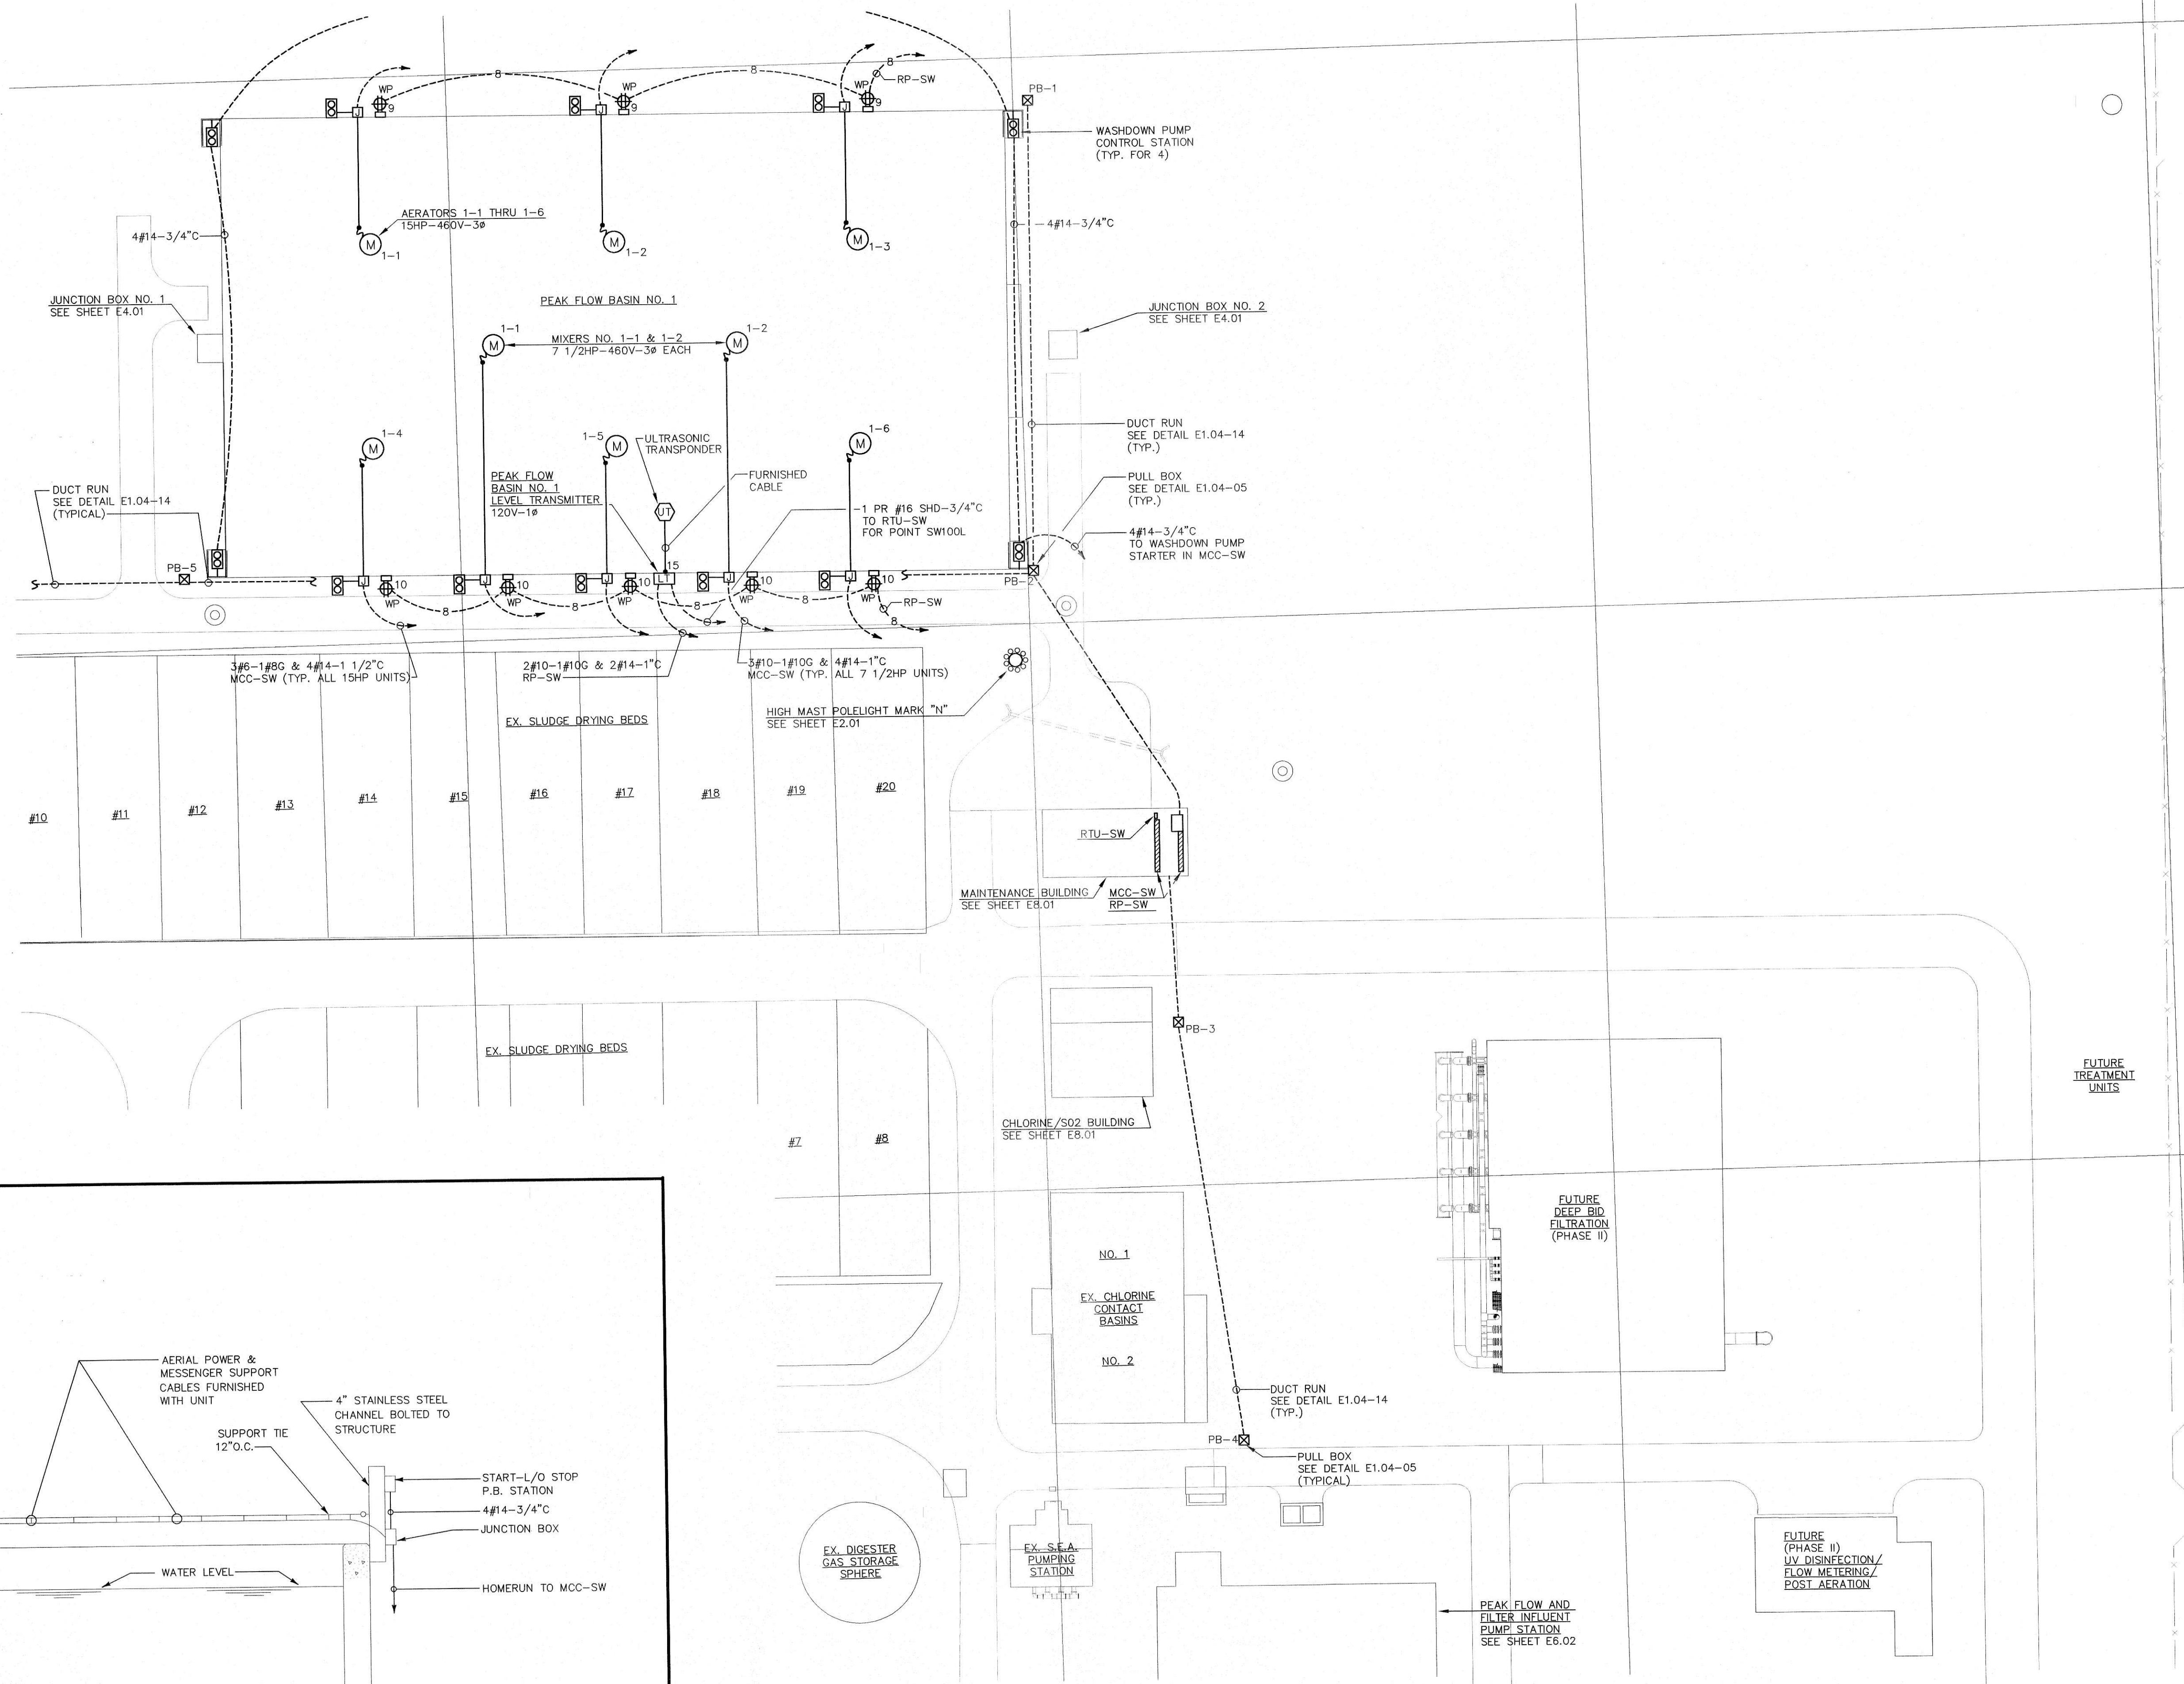


JACKSON, RENFRO & ASSOC., INC.
141 VILLAGE STREET • SUITE 1
BIRMINGHAM, ALABAMA 35242
JRA JOB NO. 99002

SCALE: 1" = 30'-0"

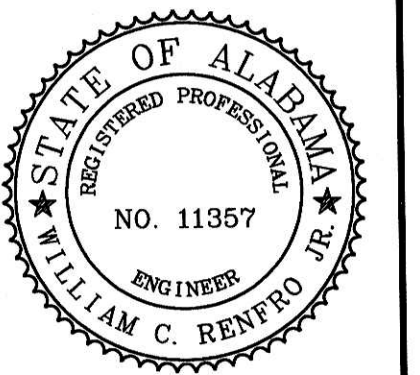

WATER WORKS & SEWER BOARD
CITY OF ANNISTON
CHOCOLOCCO WWTP
IMPROVEMENTS
ANNISTON, ALABAMA

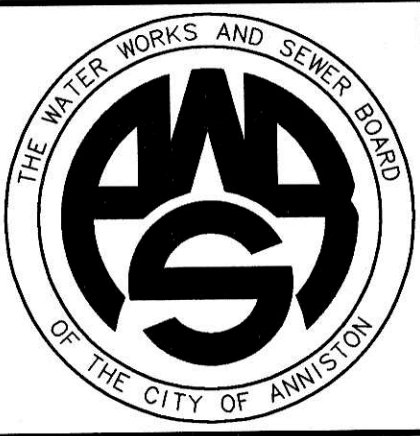

PROJECT NO.	98062
DESIGNED	WCR
DRAWN	CAB
CHECKED	WCR
APPROVED	

DATE JULY 1999

REVISIONS		
NO.	DATE	DESCRIPTION
1	11-17-06	RECORD DRAWING


RECORD
DRAWING

SHEET TITLE
GRIT BASINS &
JUNCTION BOXES
ELECTRICAL PLANS


SHEET NO.

E4.01


SEQUENCE 80 OF 84

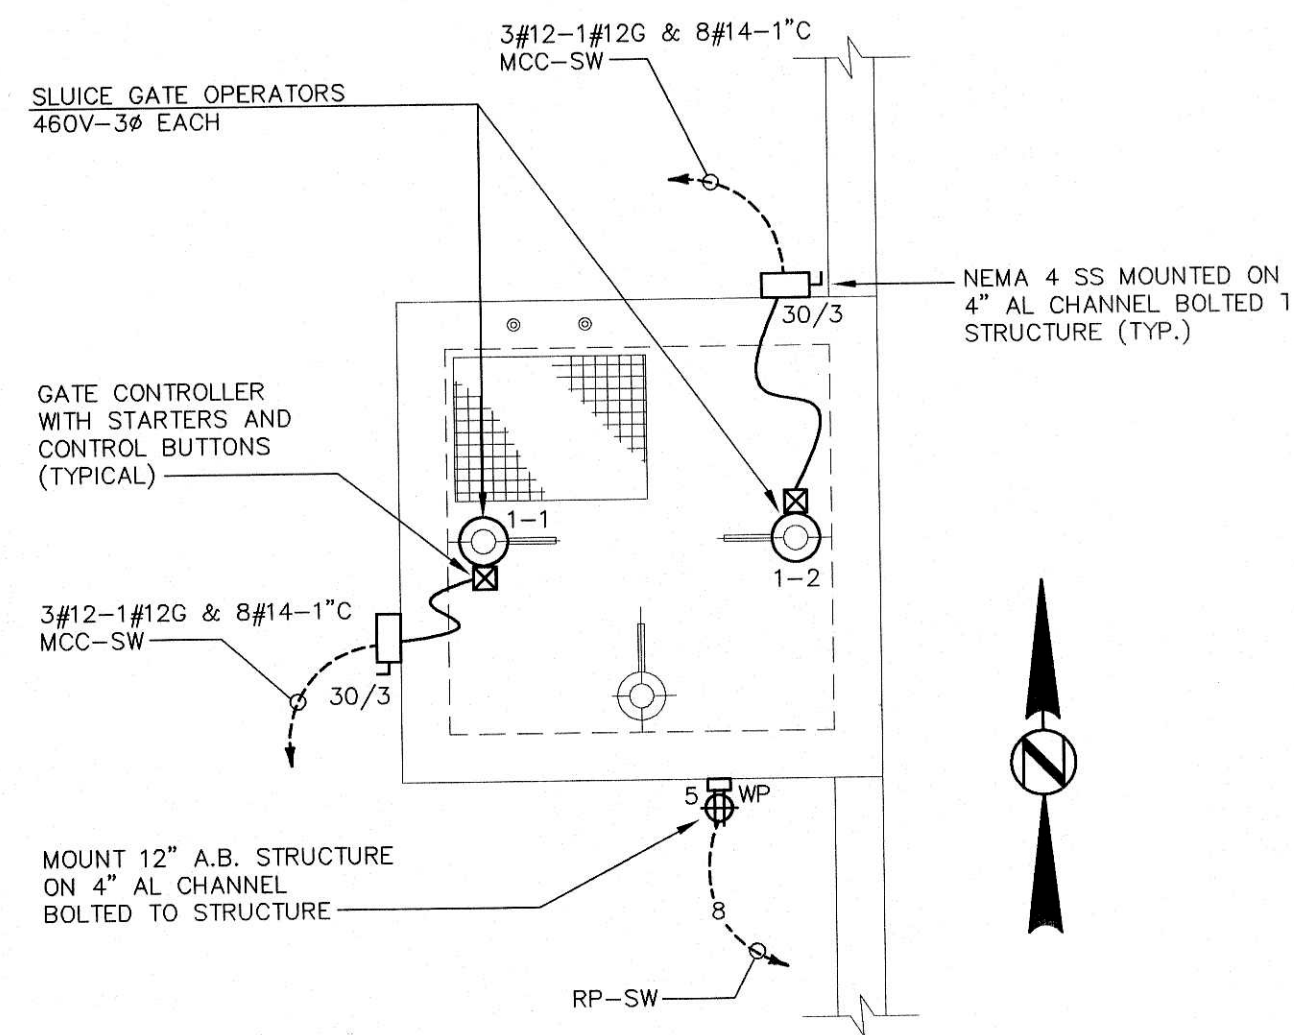

10 J.B. NO.1 ELECTRICAL PLAN SCALE : 1/4" = 1'-0"

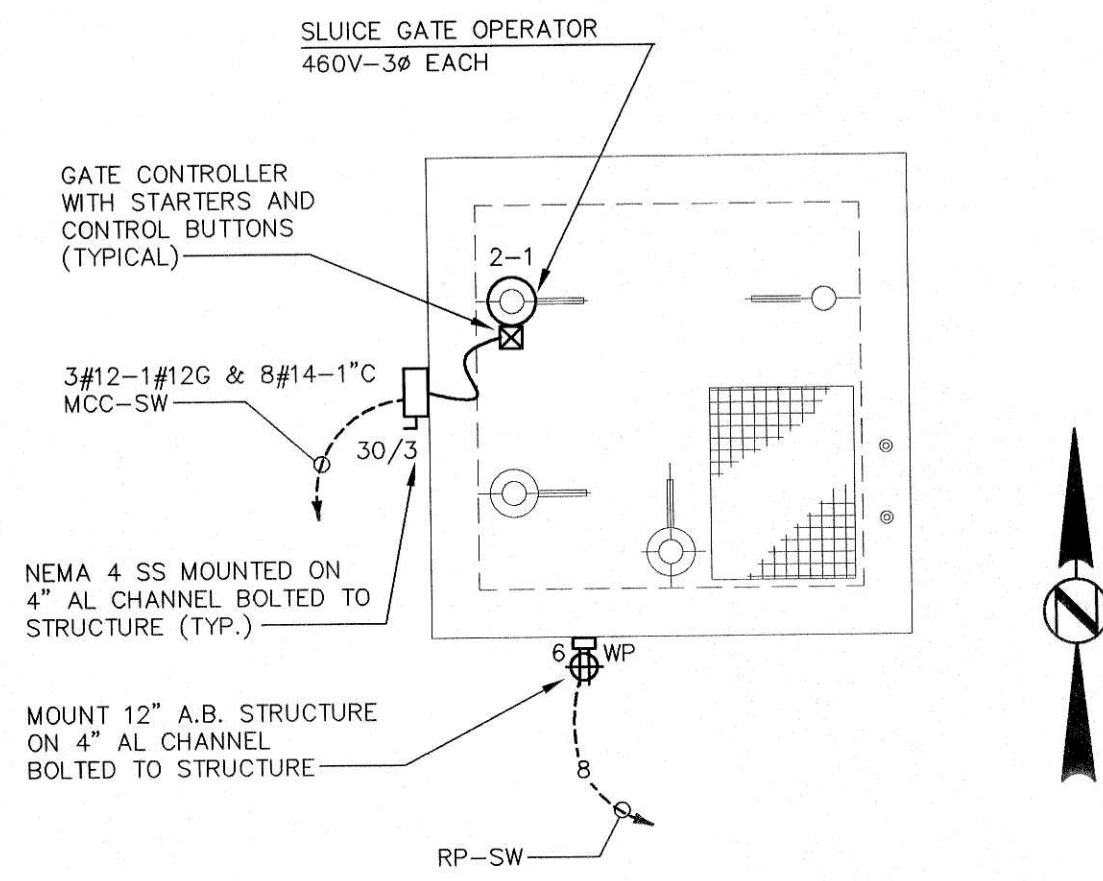


09 J.B. NO. 2 ELECTRICAL PLAN SCALE : 1/4" = 1'-0"

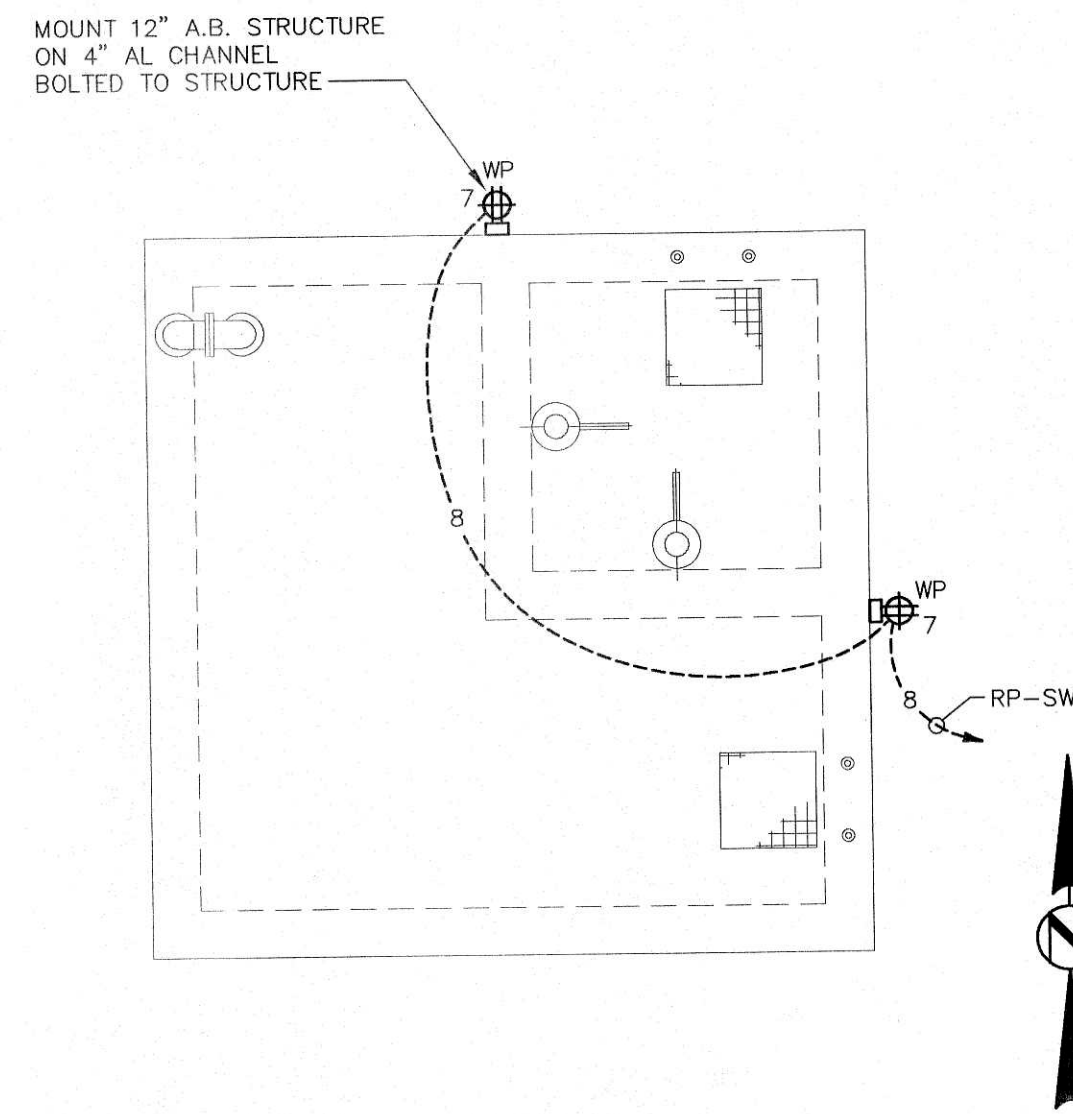


08 J.B. NO. 3 ELECTRICAL PLAN SCALE : 1/4" = 1'-0"

06 J.B. NO. 4 ELECTRICAL PLAN SCALE : 1/4" = 1'-0"

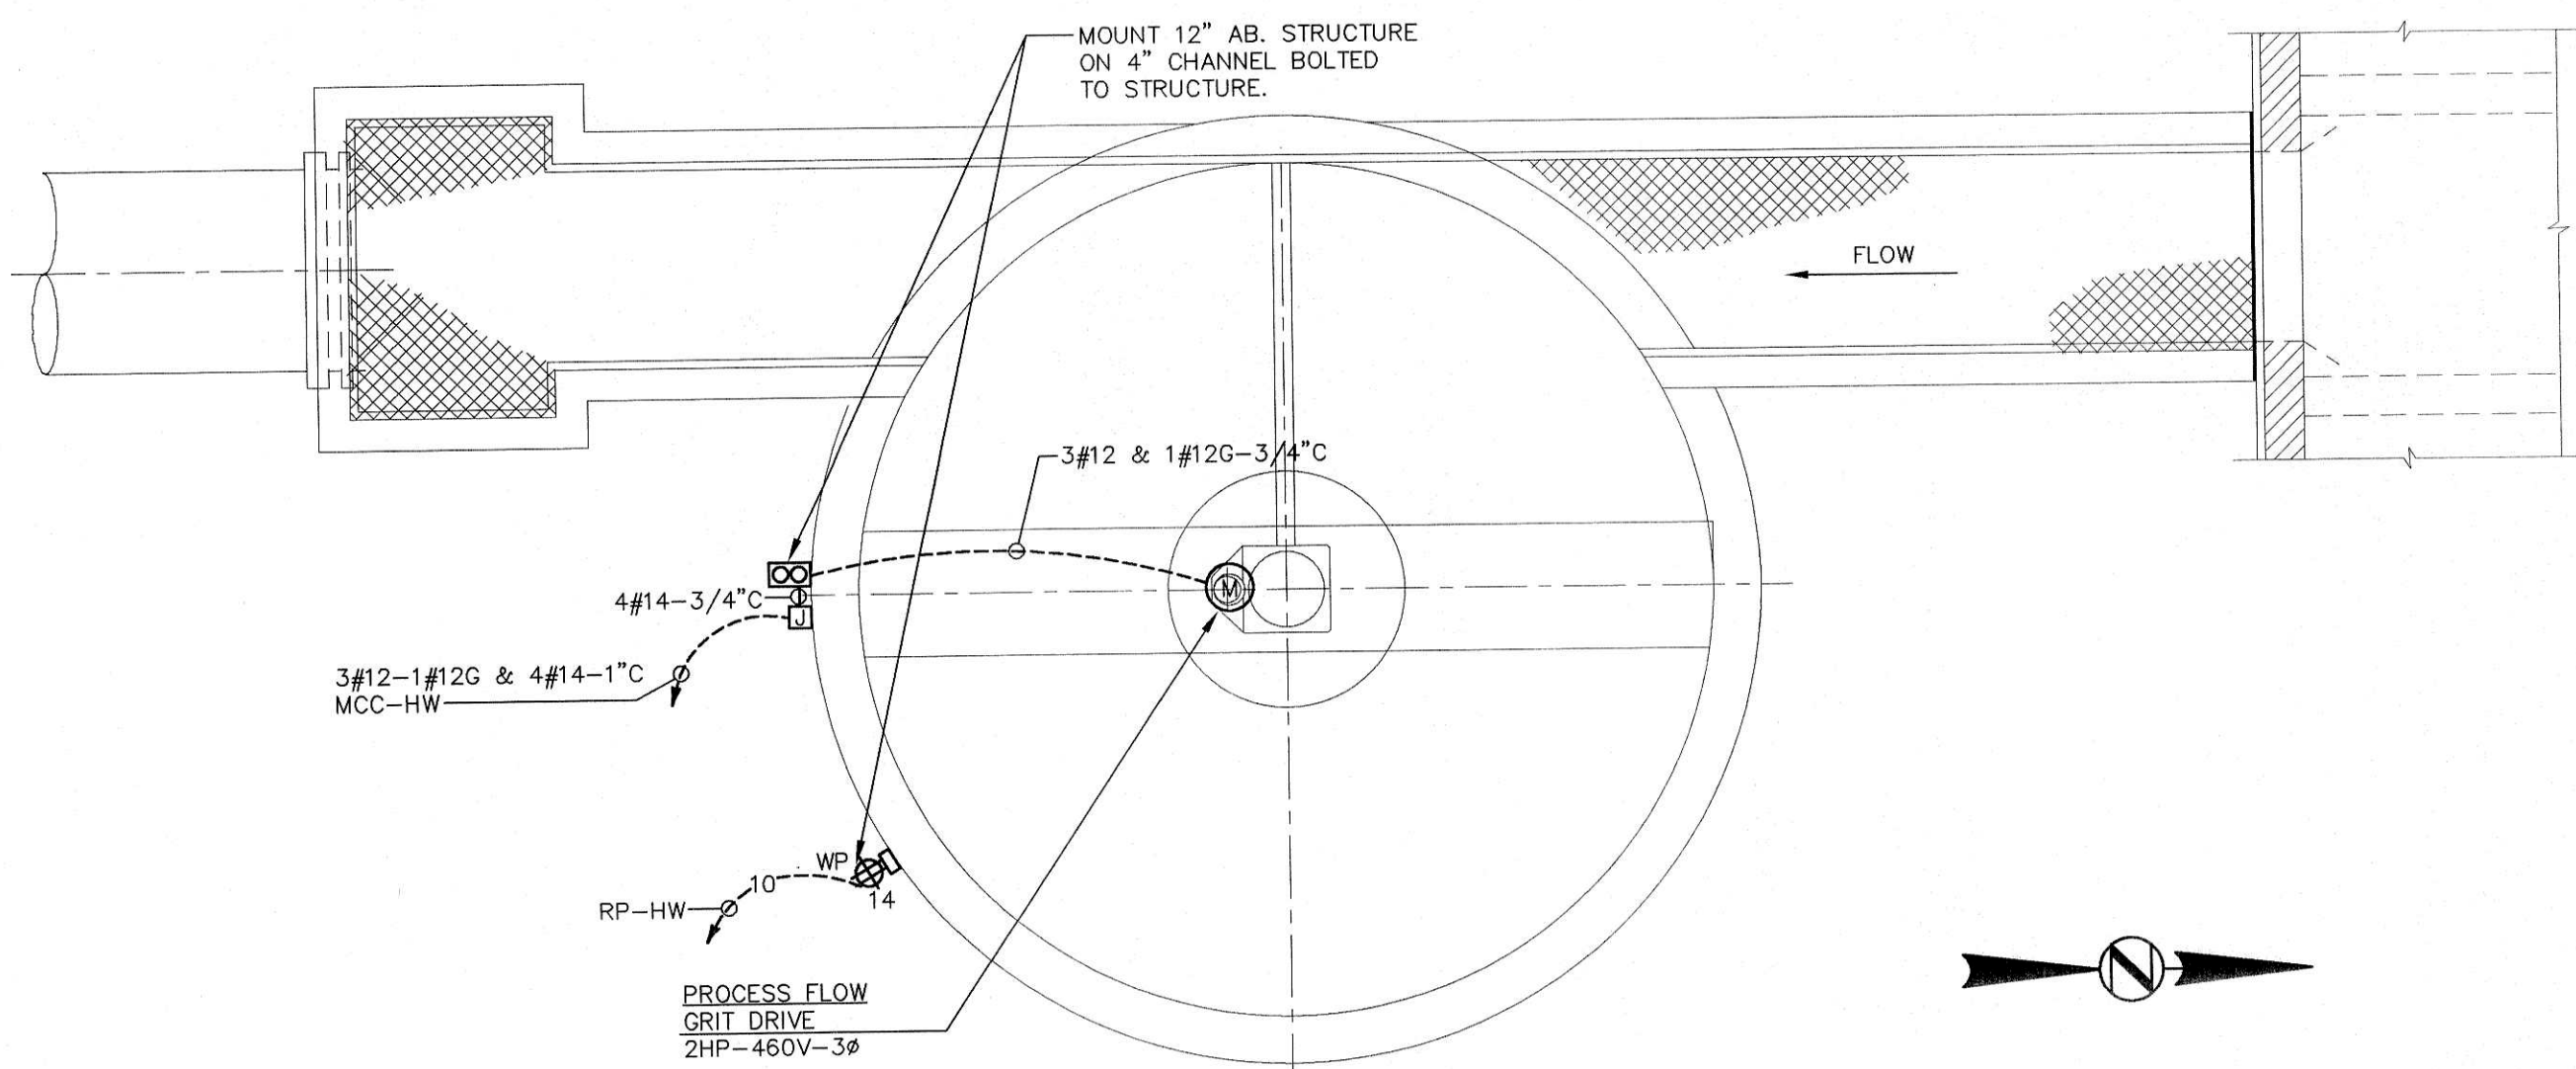


05 PROCESS FLOW GRIT BASIN ELECTRICAL PLAN

SCALE : 1/4" = 1'-0"

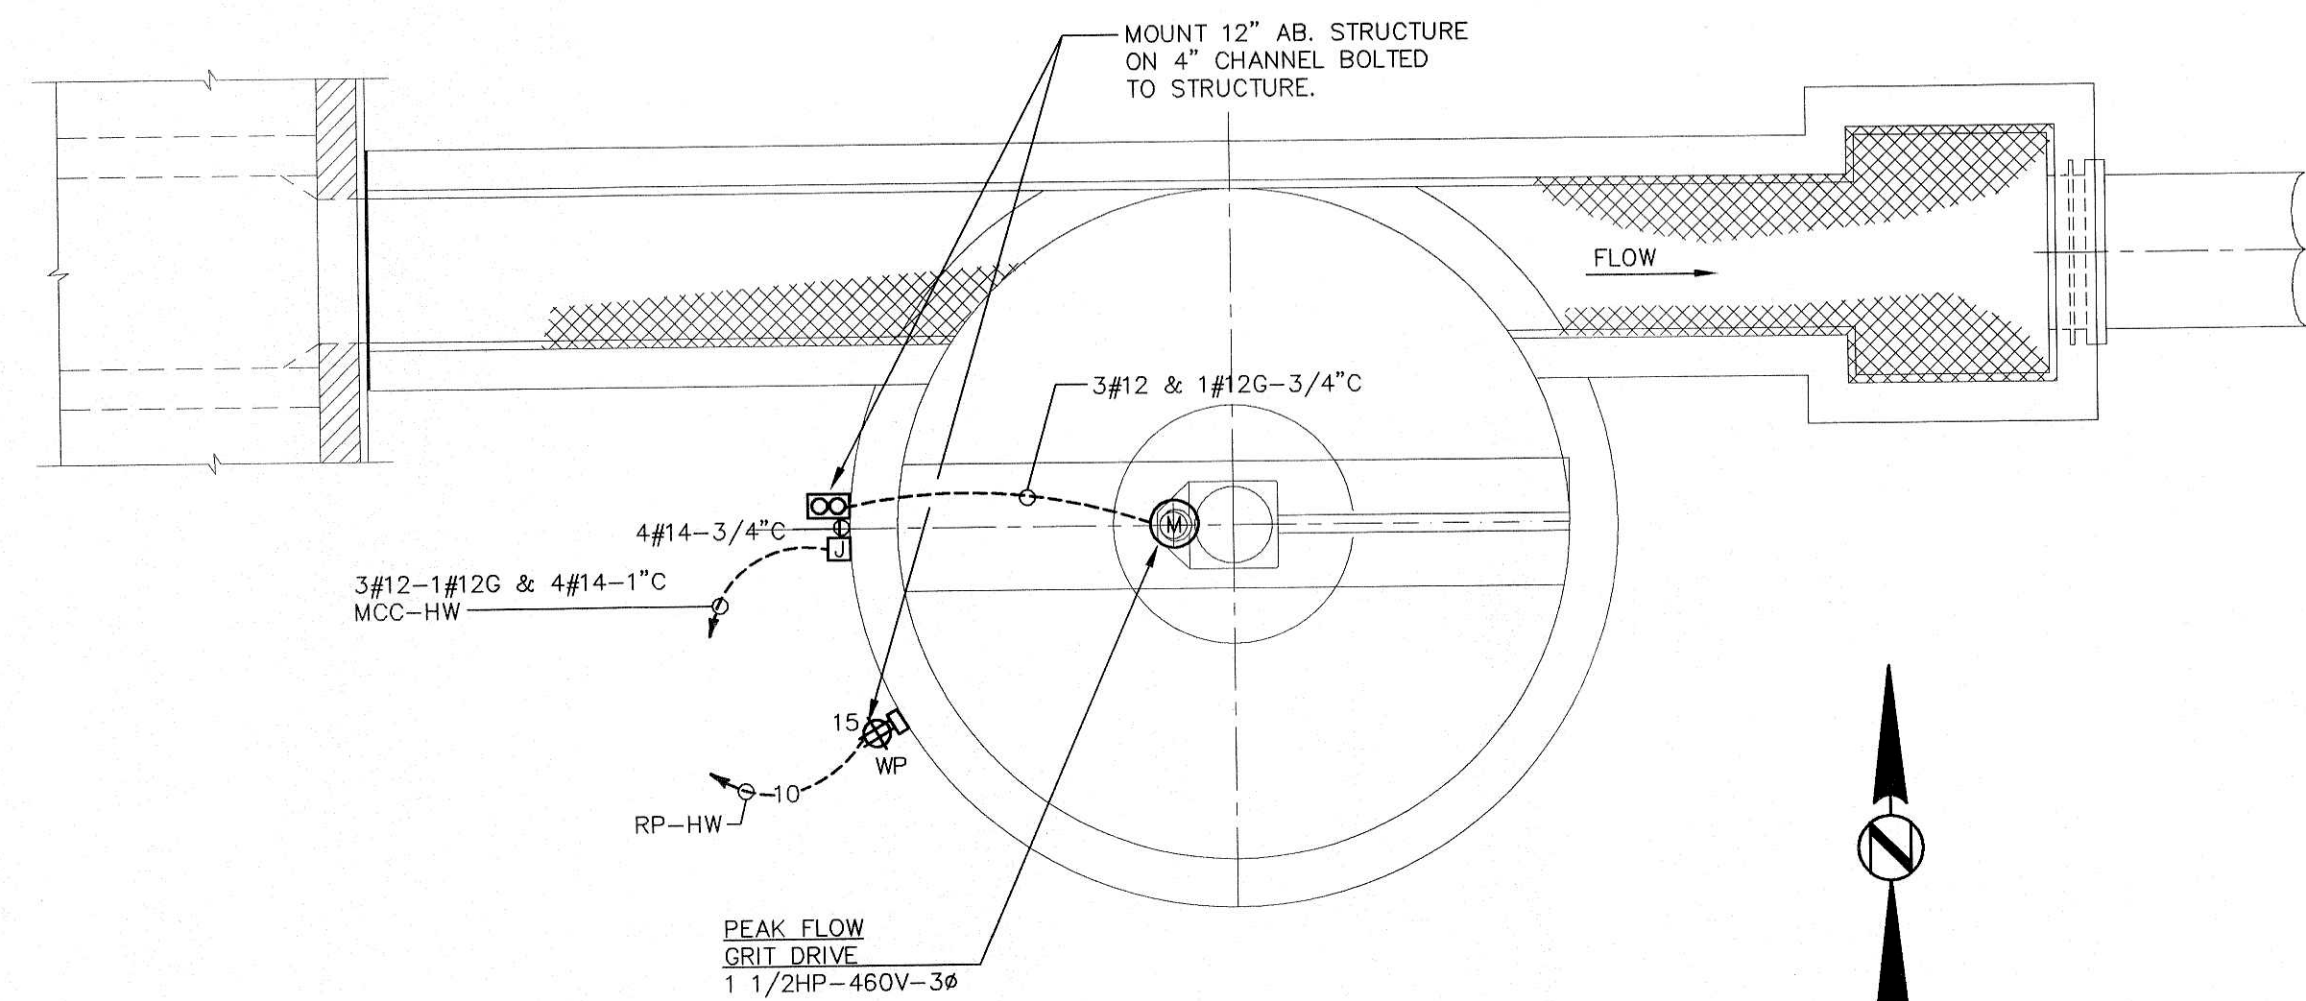

02 PEAK FLOW GRIT BASIN ELECTRICAL PLAN


SCALE : 1/4" = 1'-0"

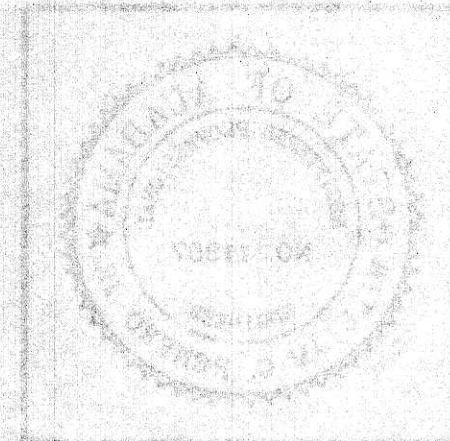

14-01



WATER WORKS & SEWER BOARD
CITY OF ANNISTON
CHOCOLOCCO WWTP
IMPROVEMENTS
ANNISTON, ALABAMA

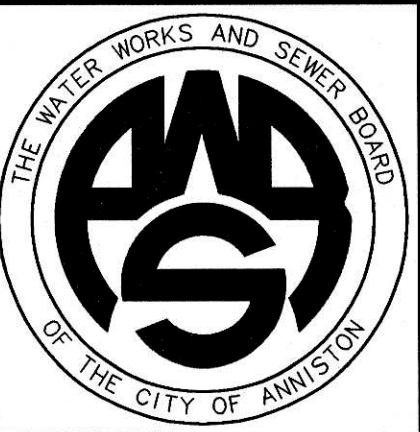


PROJECT NO.		
98062		
DESIGNED		
WCR		
DRAWN		
CAB		
CHECKED		
WCR		
APPROVED		
DATE		
JULY 1999		
REVISIONS		
NO.	DATE	DESCRIPTION
1	11-17-06	RECORD DRAWING


RECORD
DRAWING

SHEET TITLE
GRIT BASINS &
JUNCTION BOXES
ELECTRICAL PLANS


SHEET NO.
E4.01
SEQUENCE 80 OF 84

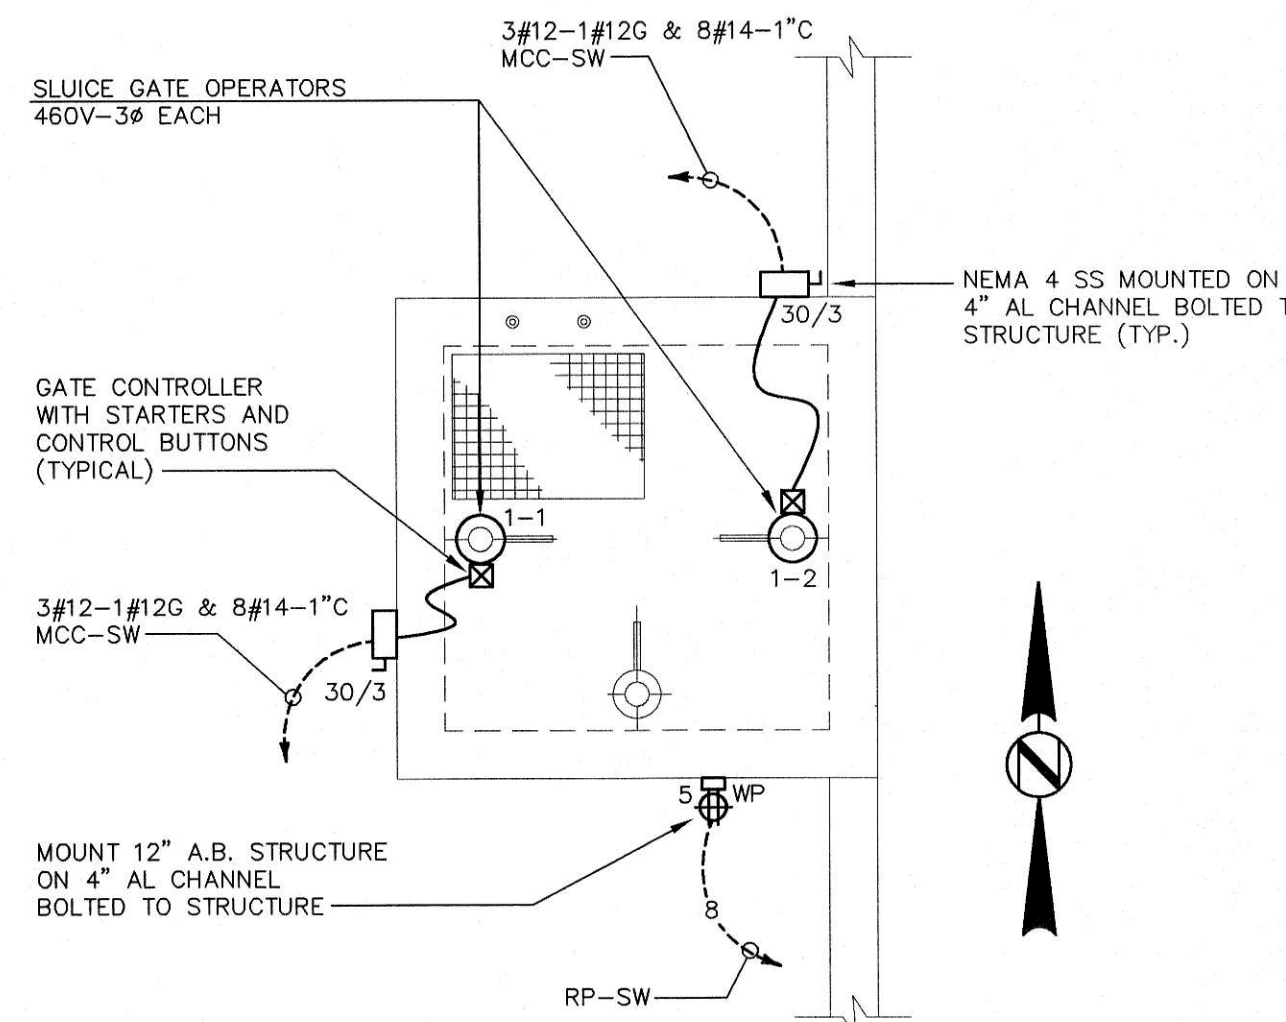


10 J.B. NO.1 ELECTRICAL PLAN SCALE : 1/4" = 1'-0"

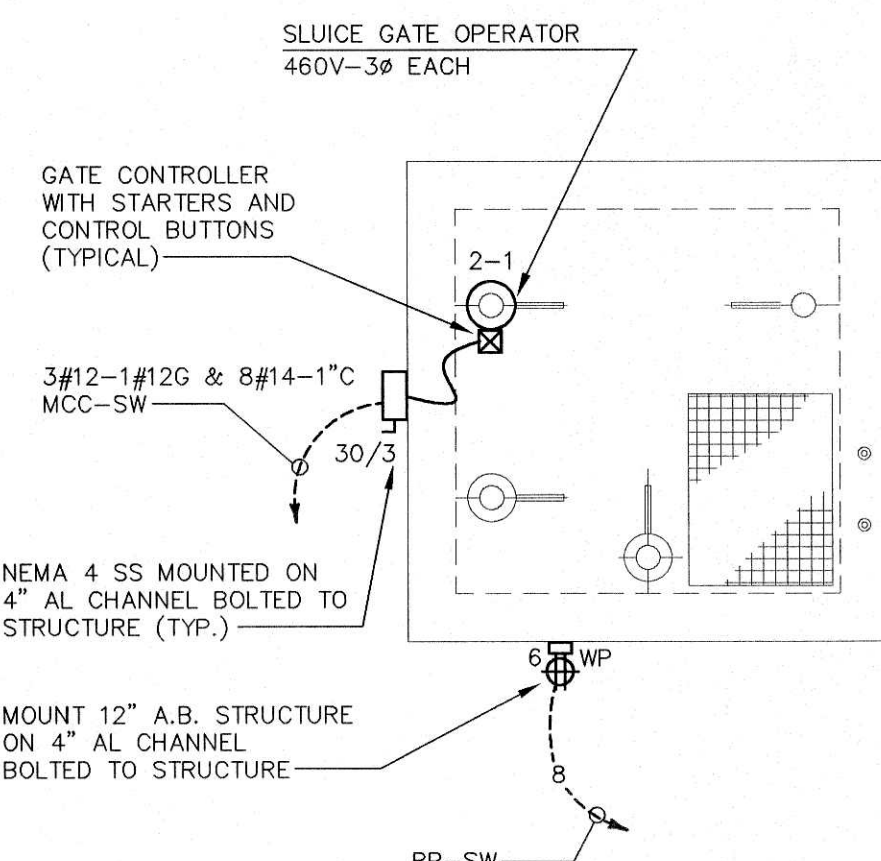


09 J.B. NO. 2 ELECTRICAL PLAN SCALE : 1/4" = 1'-0"

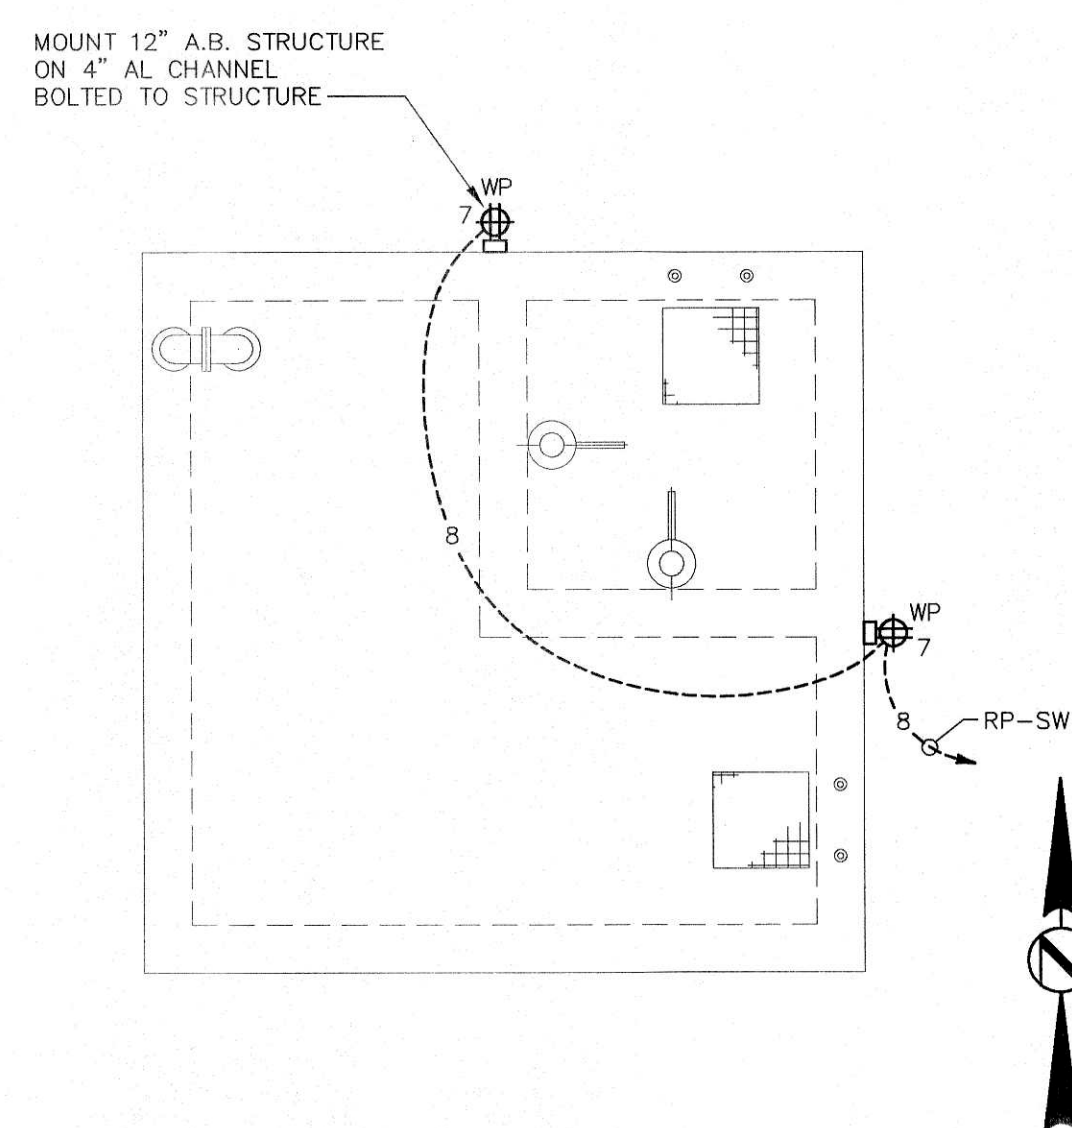

08 J.B. NO. 3 ELECTRICAL PLAN SCALE : 1/4" = 1'-0"

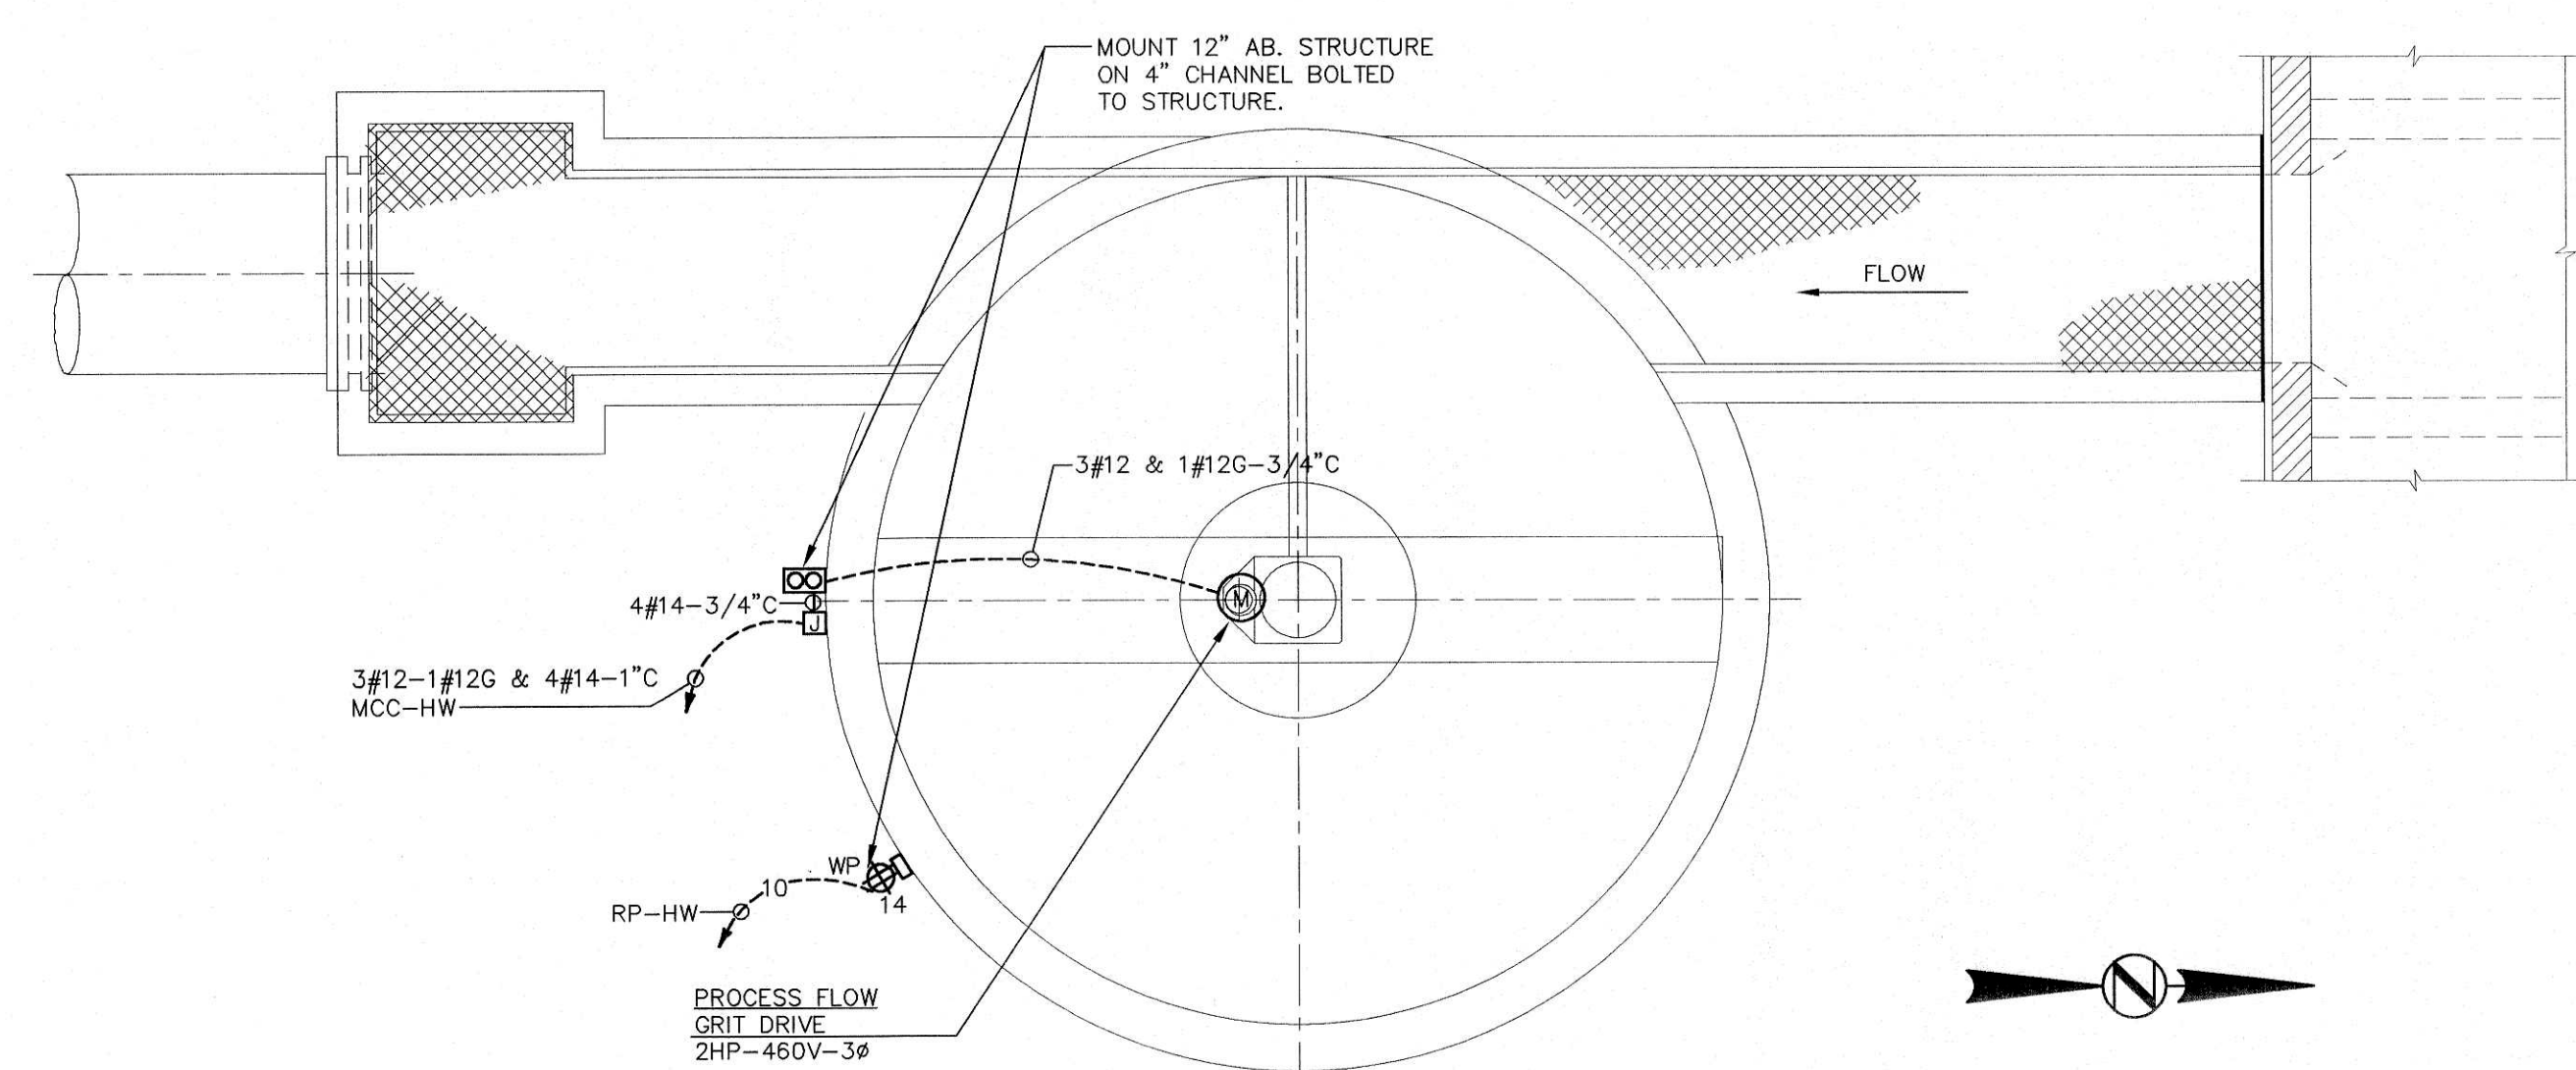


05 PROCESS FLOW GRIT BASIN ELECTRICAL PLAN SCALE : 1/4" = 1'-0"

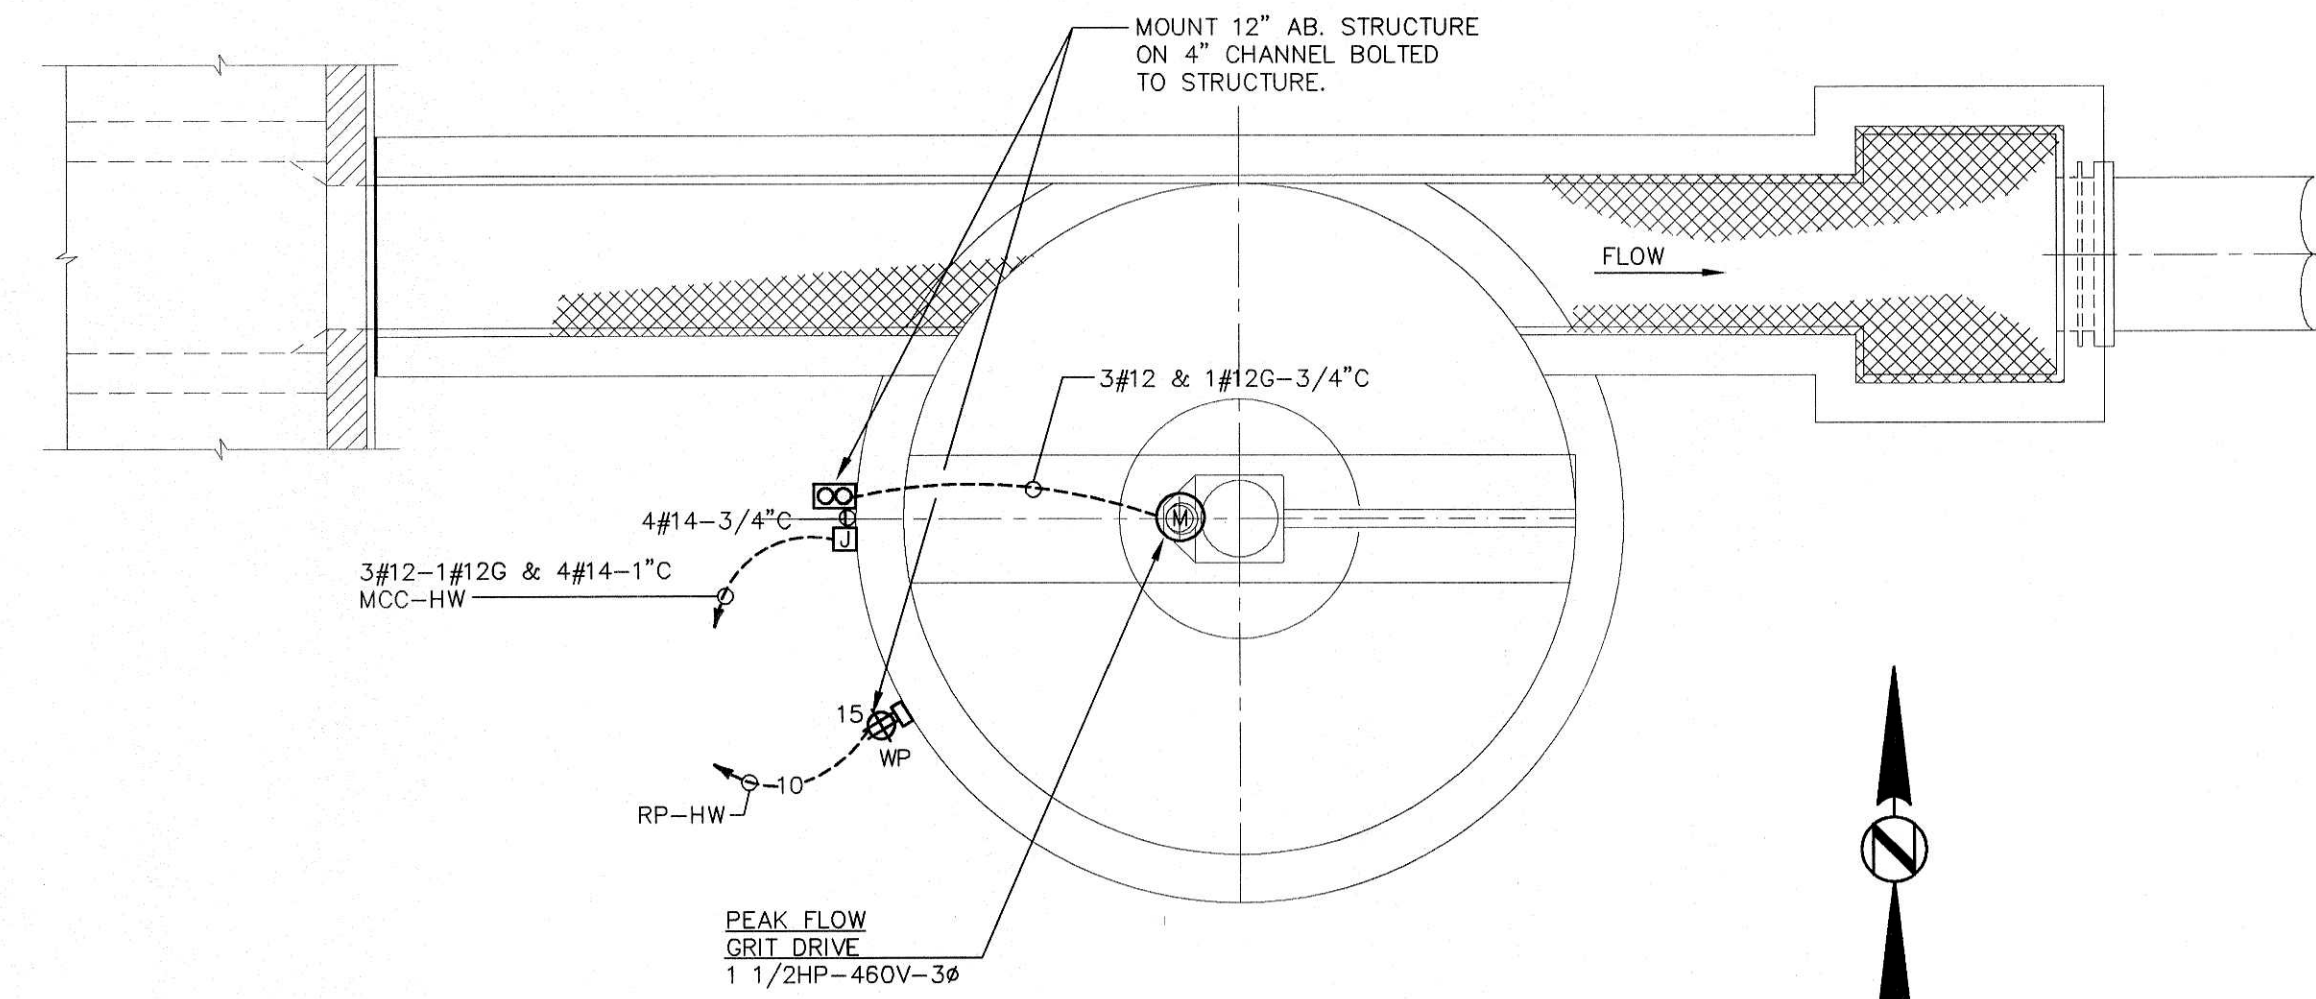

02 PEAK FLOW GRIT BASIN ELECTRICAL PLAN SCALE : 1/4" = 1'-0"

JACKSON, RENFRO & ASSOC., INC.
141 VILLAGE STREET • SUITE 1
BIRMINGHAM, ALABAMA 35242
JRA JOB NO. 99002

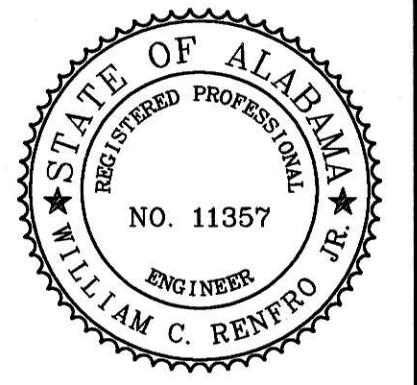

WATER WORKS & SEWER BOARD
CITY OF ANNISTON
CHOCOLOCOO WWTP
IMPROVEMENTS
ANNISTON, ALABAMA




PROJECT NO.	98062	
DESIGNED	WCR	
DRAWN	CAB	
CHECKED	WCR	
APPROVED		
DATE	JULY 1999	
REVISIONS		
NO.	DATE	DESCRIPTION
1	11-17-06	RECORD DRAWING

RECORD
DRAWING


SHEET TITLE
HEADWORKS BUILDING
ELECTRICAL PLANS

SHEET NO.
E3.01
SEQUENCE 79 OF 84

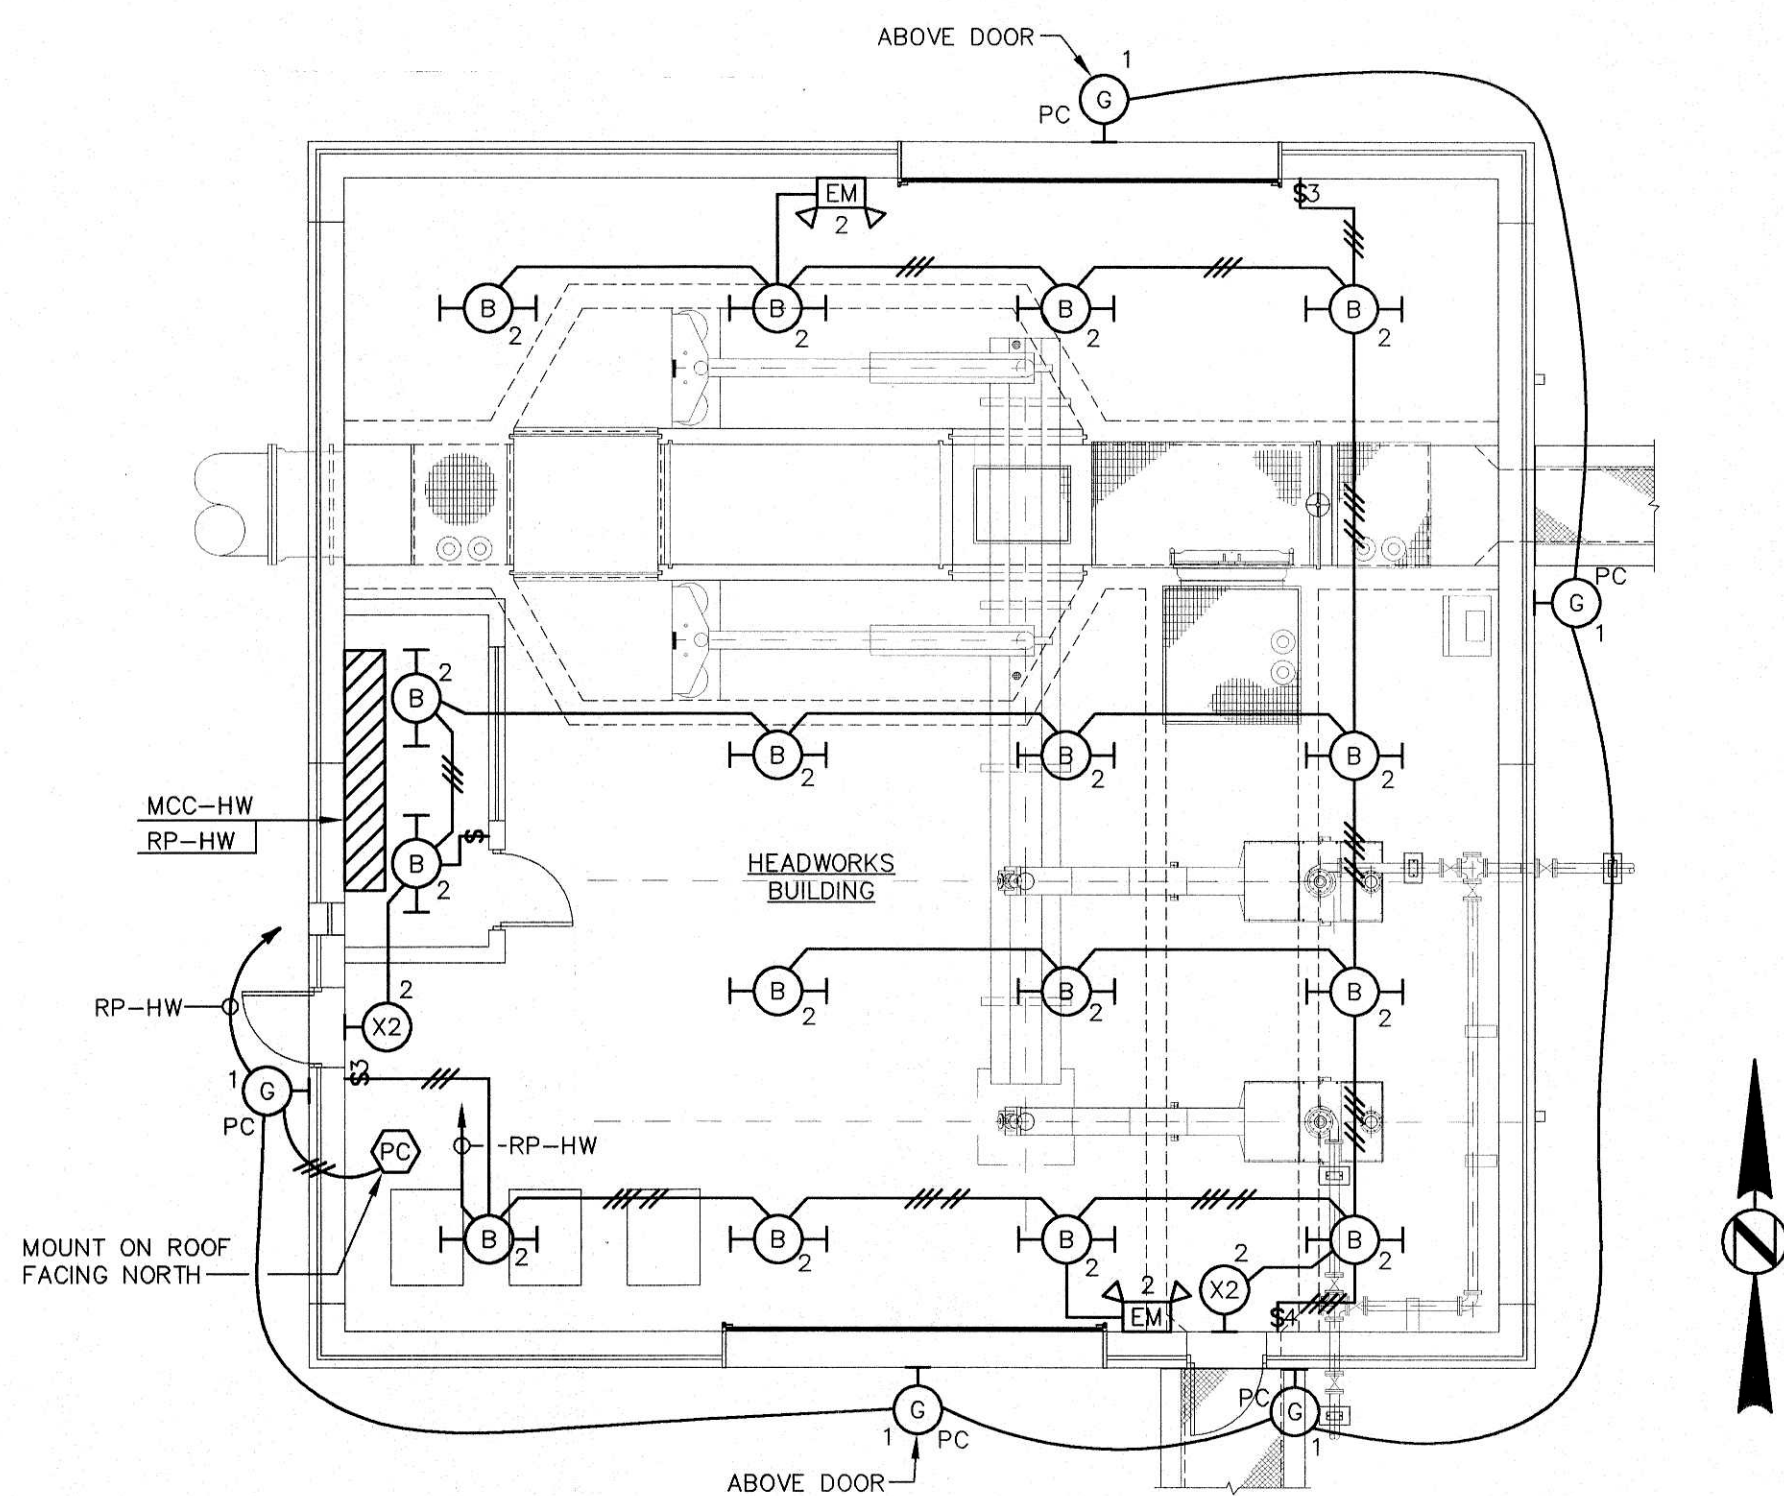

05 HEADWORKS BUILDING LIGHTING PLAN

SCALE : 1/8" = 1'-0"

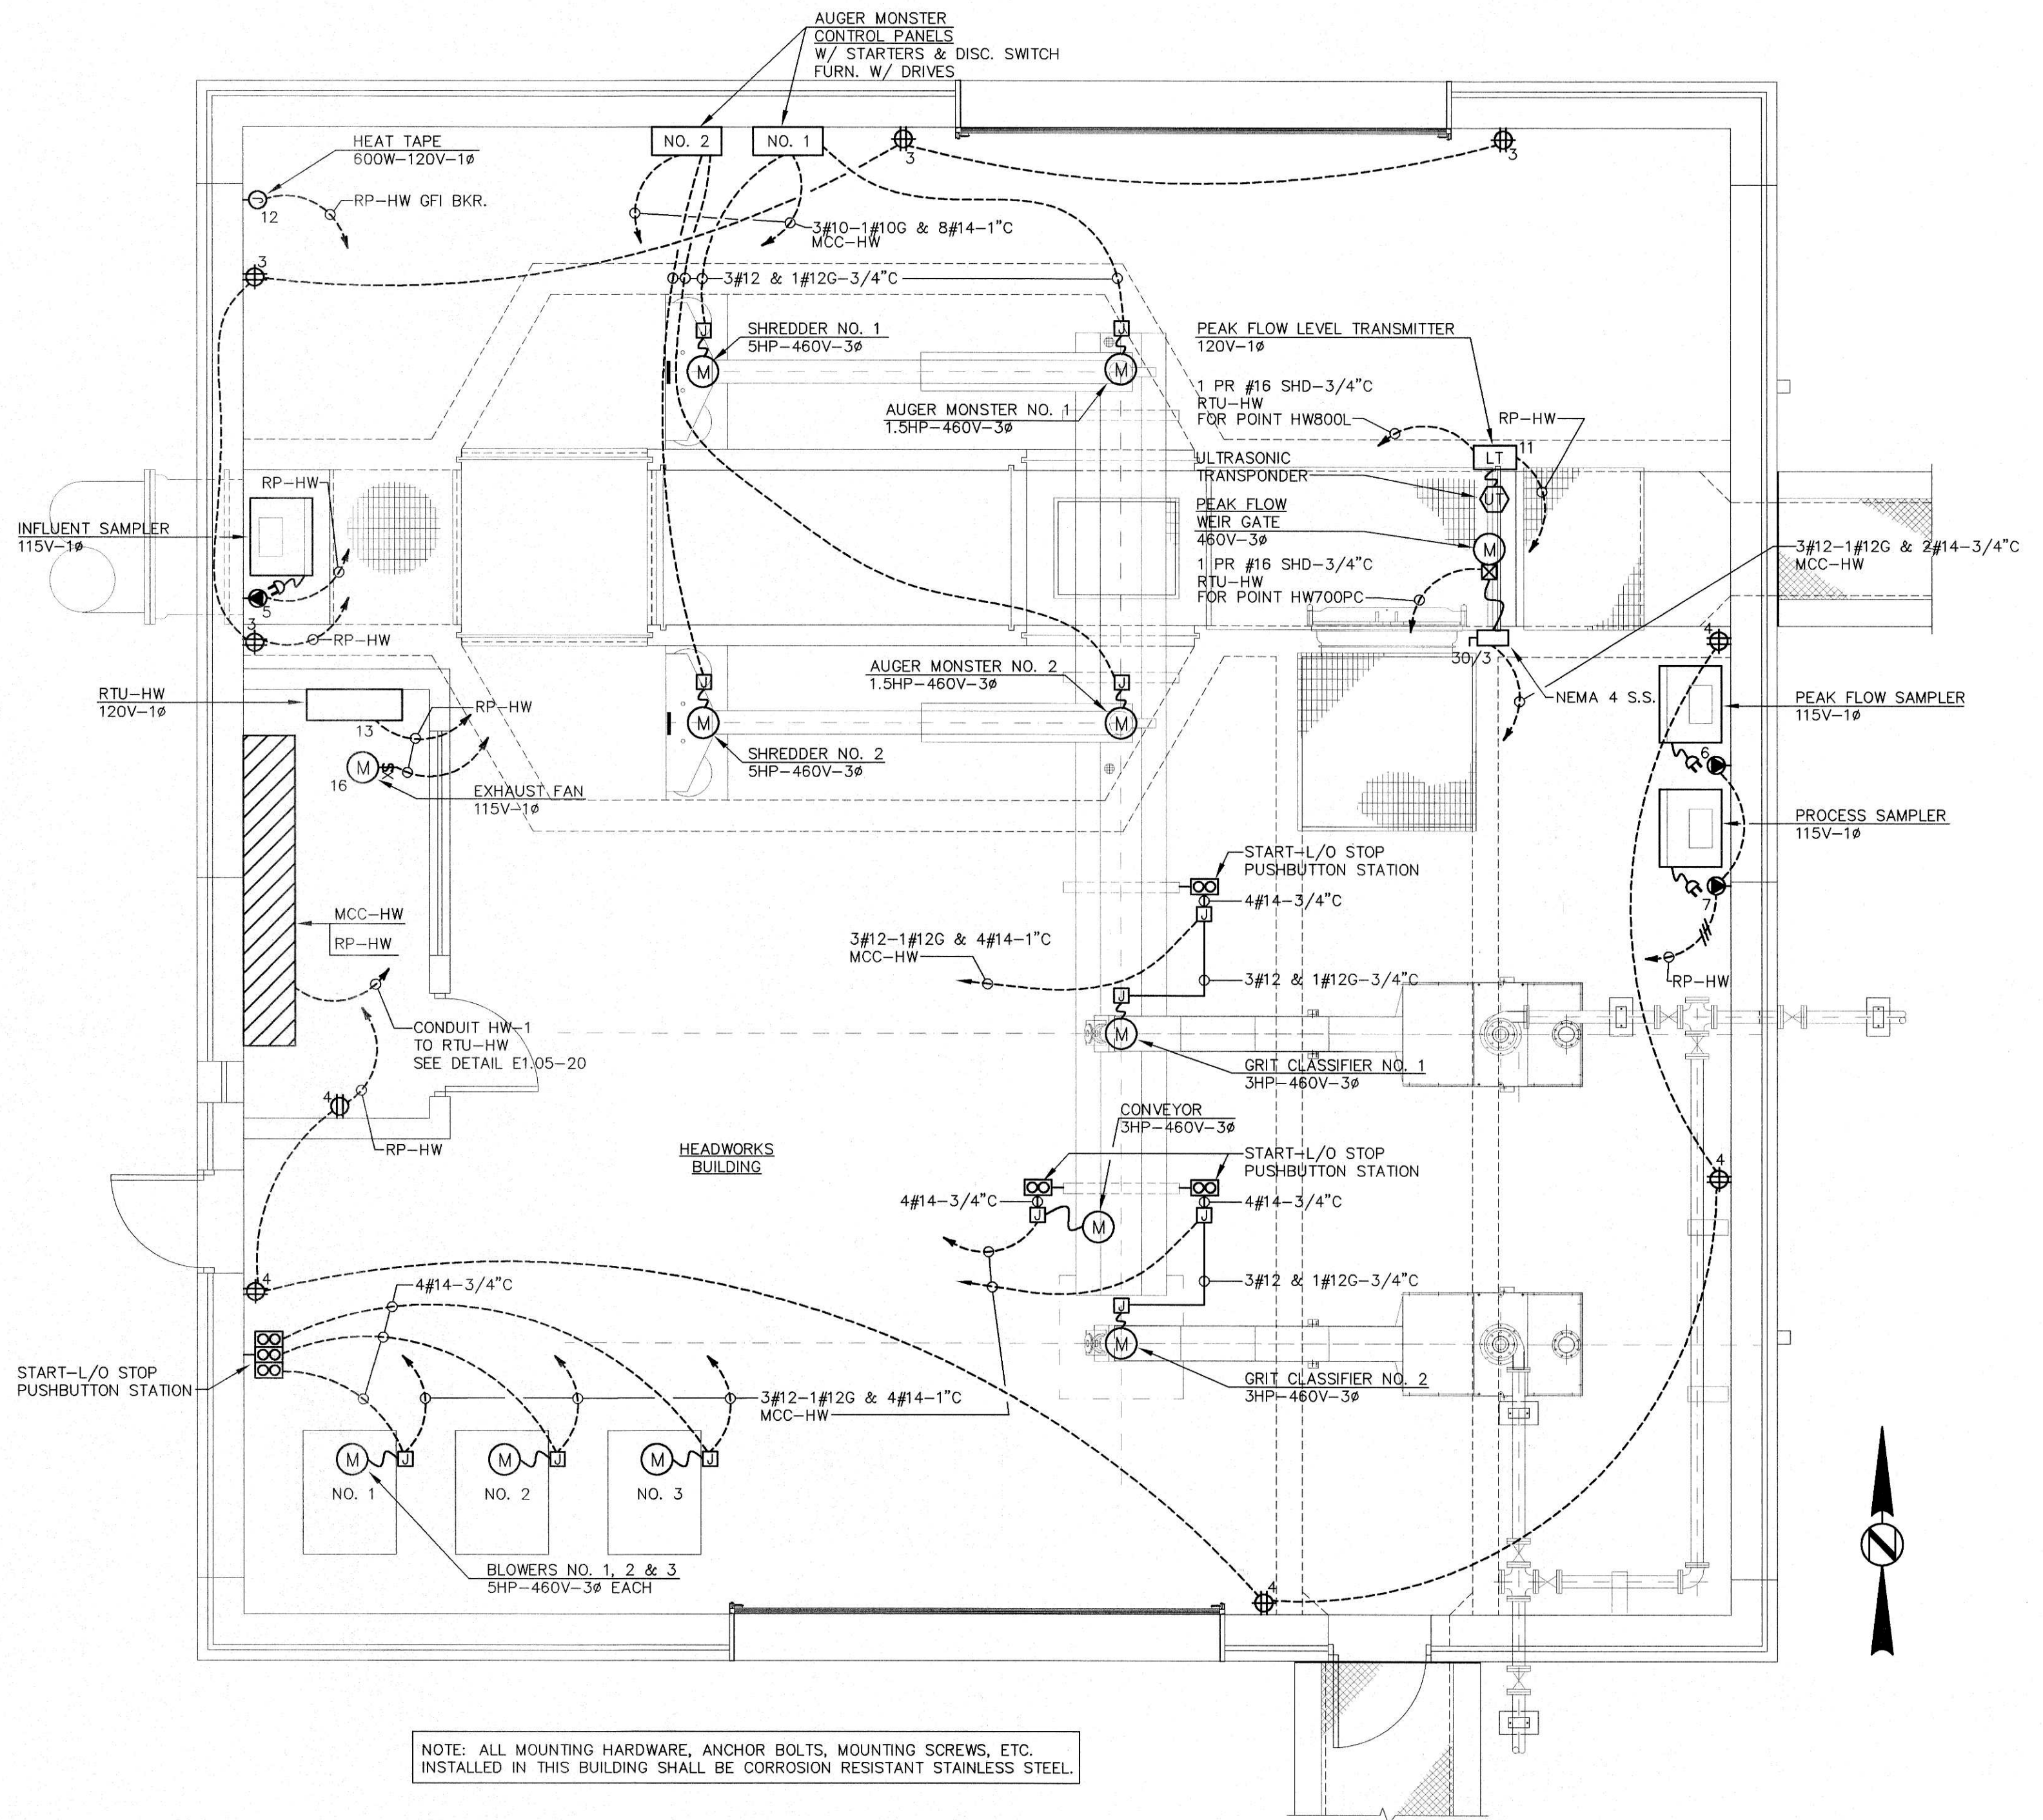


NOTE: ALL MOUNTING HARDWARE, ANCHOR BOLTS, MOUNTING SCREWS, ETC.
INSTALLED IN THIS BUILDING SHALL BE CORROSION RESISTANT STAINLESS STEEL.

03 HEADWORKS BUILDING POWER PLAN

SCALE : 1/4" = 1'-0"

JACKSON, RENFRO & ASSOC., INC.
141 VILLAGE STREET • SUITE 1
BIRMINGHAM, ALABAMA 35242
JRA JOB NO. 99002

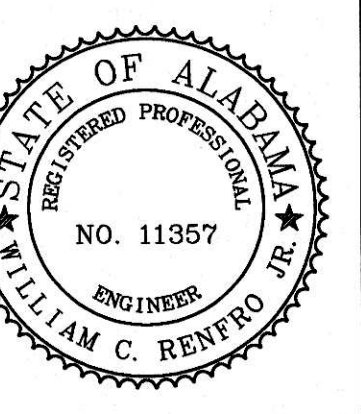

WATER WORKS & SEWER BOARD
CITY OF ANNISTON
CHOCOCCO WWTP
IMPROVEMENTS
ANNISTON, ALABAMA



PROJECT NO.	98062
DESIGNED	WCR
DRAWN	CAB
CHECKED	WCR
APPROVED	

DATE JULY 1999

NO.	DATE	DESCRIPTION
1	11-17-06	RECORD DRAWING


RECORD
DRAWING

ELECTRICAL
GROUNDING PLAN
& DETAILS
BASE BID

SHEET NO.

E2.02

SEQUENCE 78 OF 84

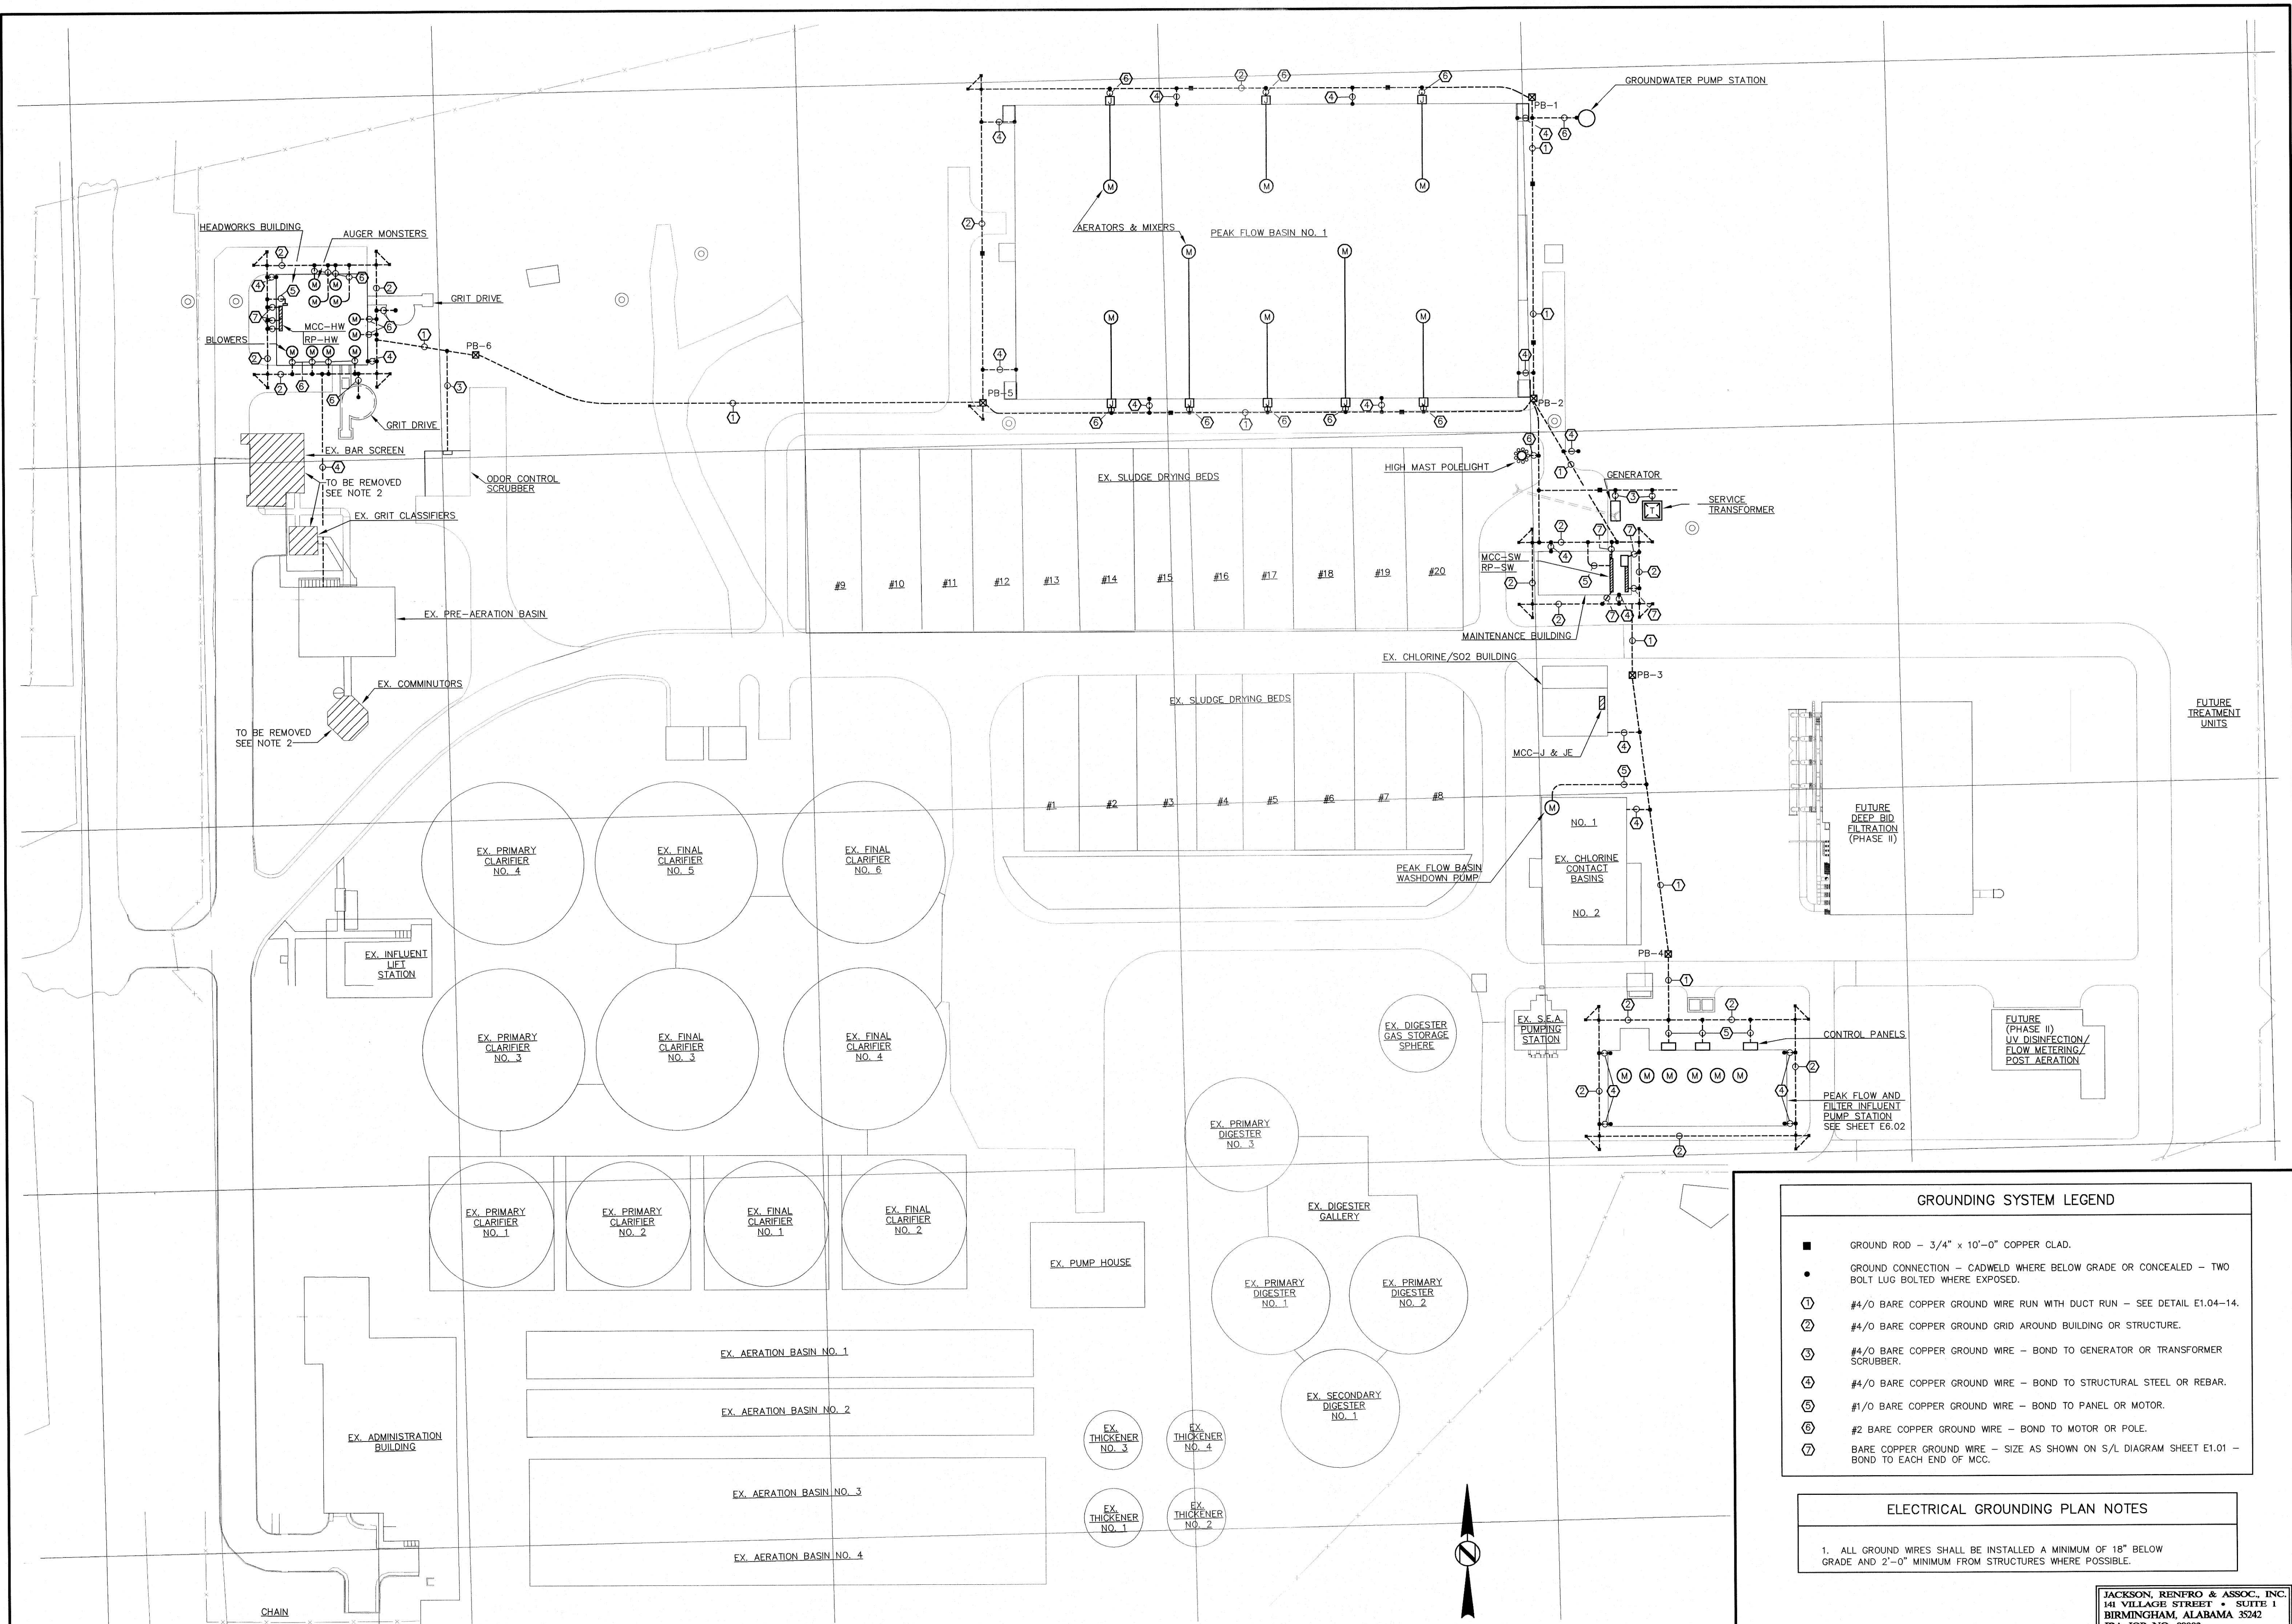


GROUNDING SYSTEM LEGEND

- GROUND ROD - 3/4" x 10'-0" COPPER CLAD.
- GROUND CONNECTION - CADWELD WHERE BELOW GRADE OR CONCEALED - TWO BOLT LUG BOLTED WHERE EXPOSED.
- ① #4/0 BARE COPPER GROUND WIRE RUN WITH DUCT RUN - SEE DETAIL E1.04-14.
- ② #4/0 BARE COPPER GROUND GRID AROUND BUILDING OR STRUCTURE.
- ③ #4/0 BARE COPPER GROUND WIRE - BOND TO GENERATOR OR TRANSFORMER SCRUBBER.
- ④ #4/0 BARE COPPER GROUND WIRE - BOND TO STRUCTURAL STEEL OR REBAR.
- ⑤ #1/0 BARE COPPER GROUND WIRE - BOND TO PANEL OR MOTOR.
- ⑥ #2 BARE COPPER GROUND WIRE - BOND TO MOTOR OR POLE.
- ⑦ BARE COPPER GROUND WIRE - SIZE AS SHOWN ON S/L DIAGRAM SHEET E1.01 - BOND TO EACH END OF MCC.


ELECTRICAL GROUNDING PLAN NOTES

1. ALL GROUND WIRES SHALL BE INSTALLED A MINIMUM OF 18" BELOW GRADE AND 2'-0" MINIMUM FROM STRUCTURES WHERE POSSIBLE.

JACKSON, RENFRO & ASSOC., INC.
141 VILLAGE STREET • SUITE 1
BIRMINGHAM, ALABAMA 35242
JRA JOB NO. 99002

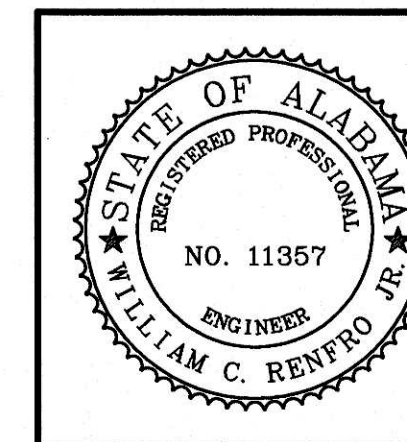


**WATER WORKS & SEWER BOARD
CITY OF ANNISTON
CHOCOLOCCO WWTP
IMPROVEMENTS**

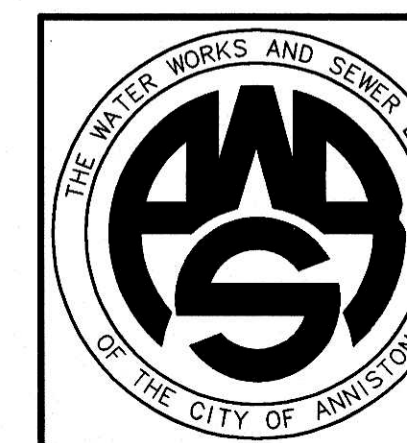


PROJECT NO.		
98062		
DESIGNED		
WCR		
DRAWN		
CAB		
CHECKED		
WCR		
APPROVED		
DATE		
JULY 1999		
REVISIONS		
NO.	DATE	DESCRIPTION
1	11-17-06	RECORD DRAWING

**RECORD
DRAWING**

SHEET TITLE	ELECTRICAL SITE PLAN & DETAILS
SHEET NO.	E2.01
SEQUENCE	77 OF 84

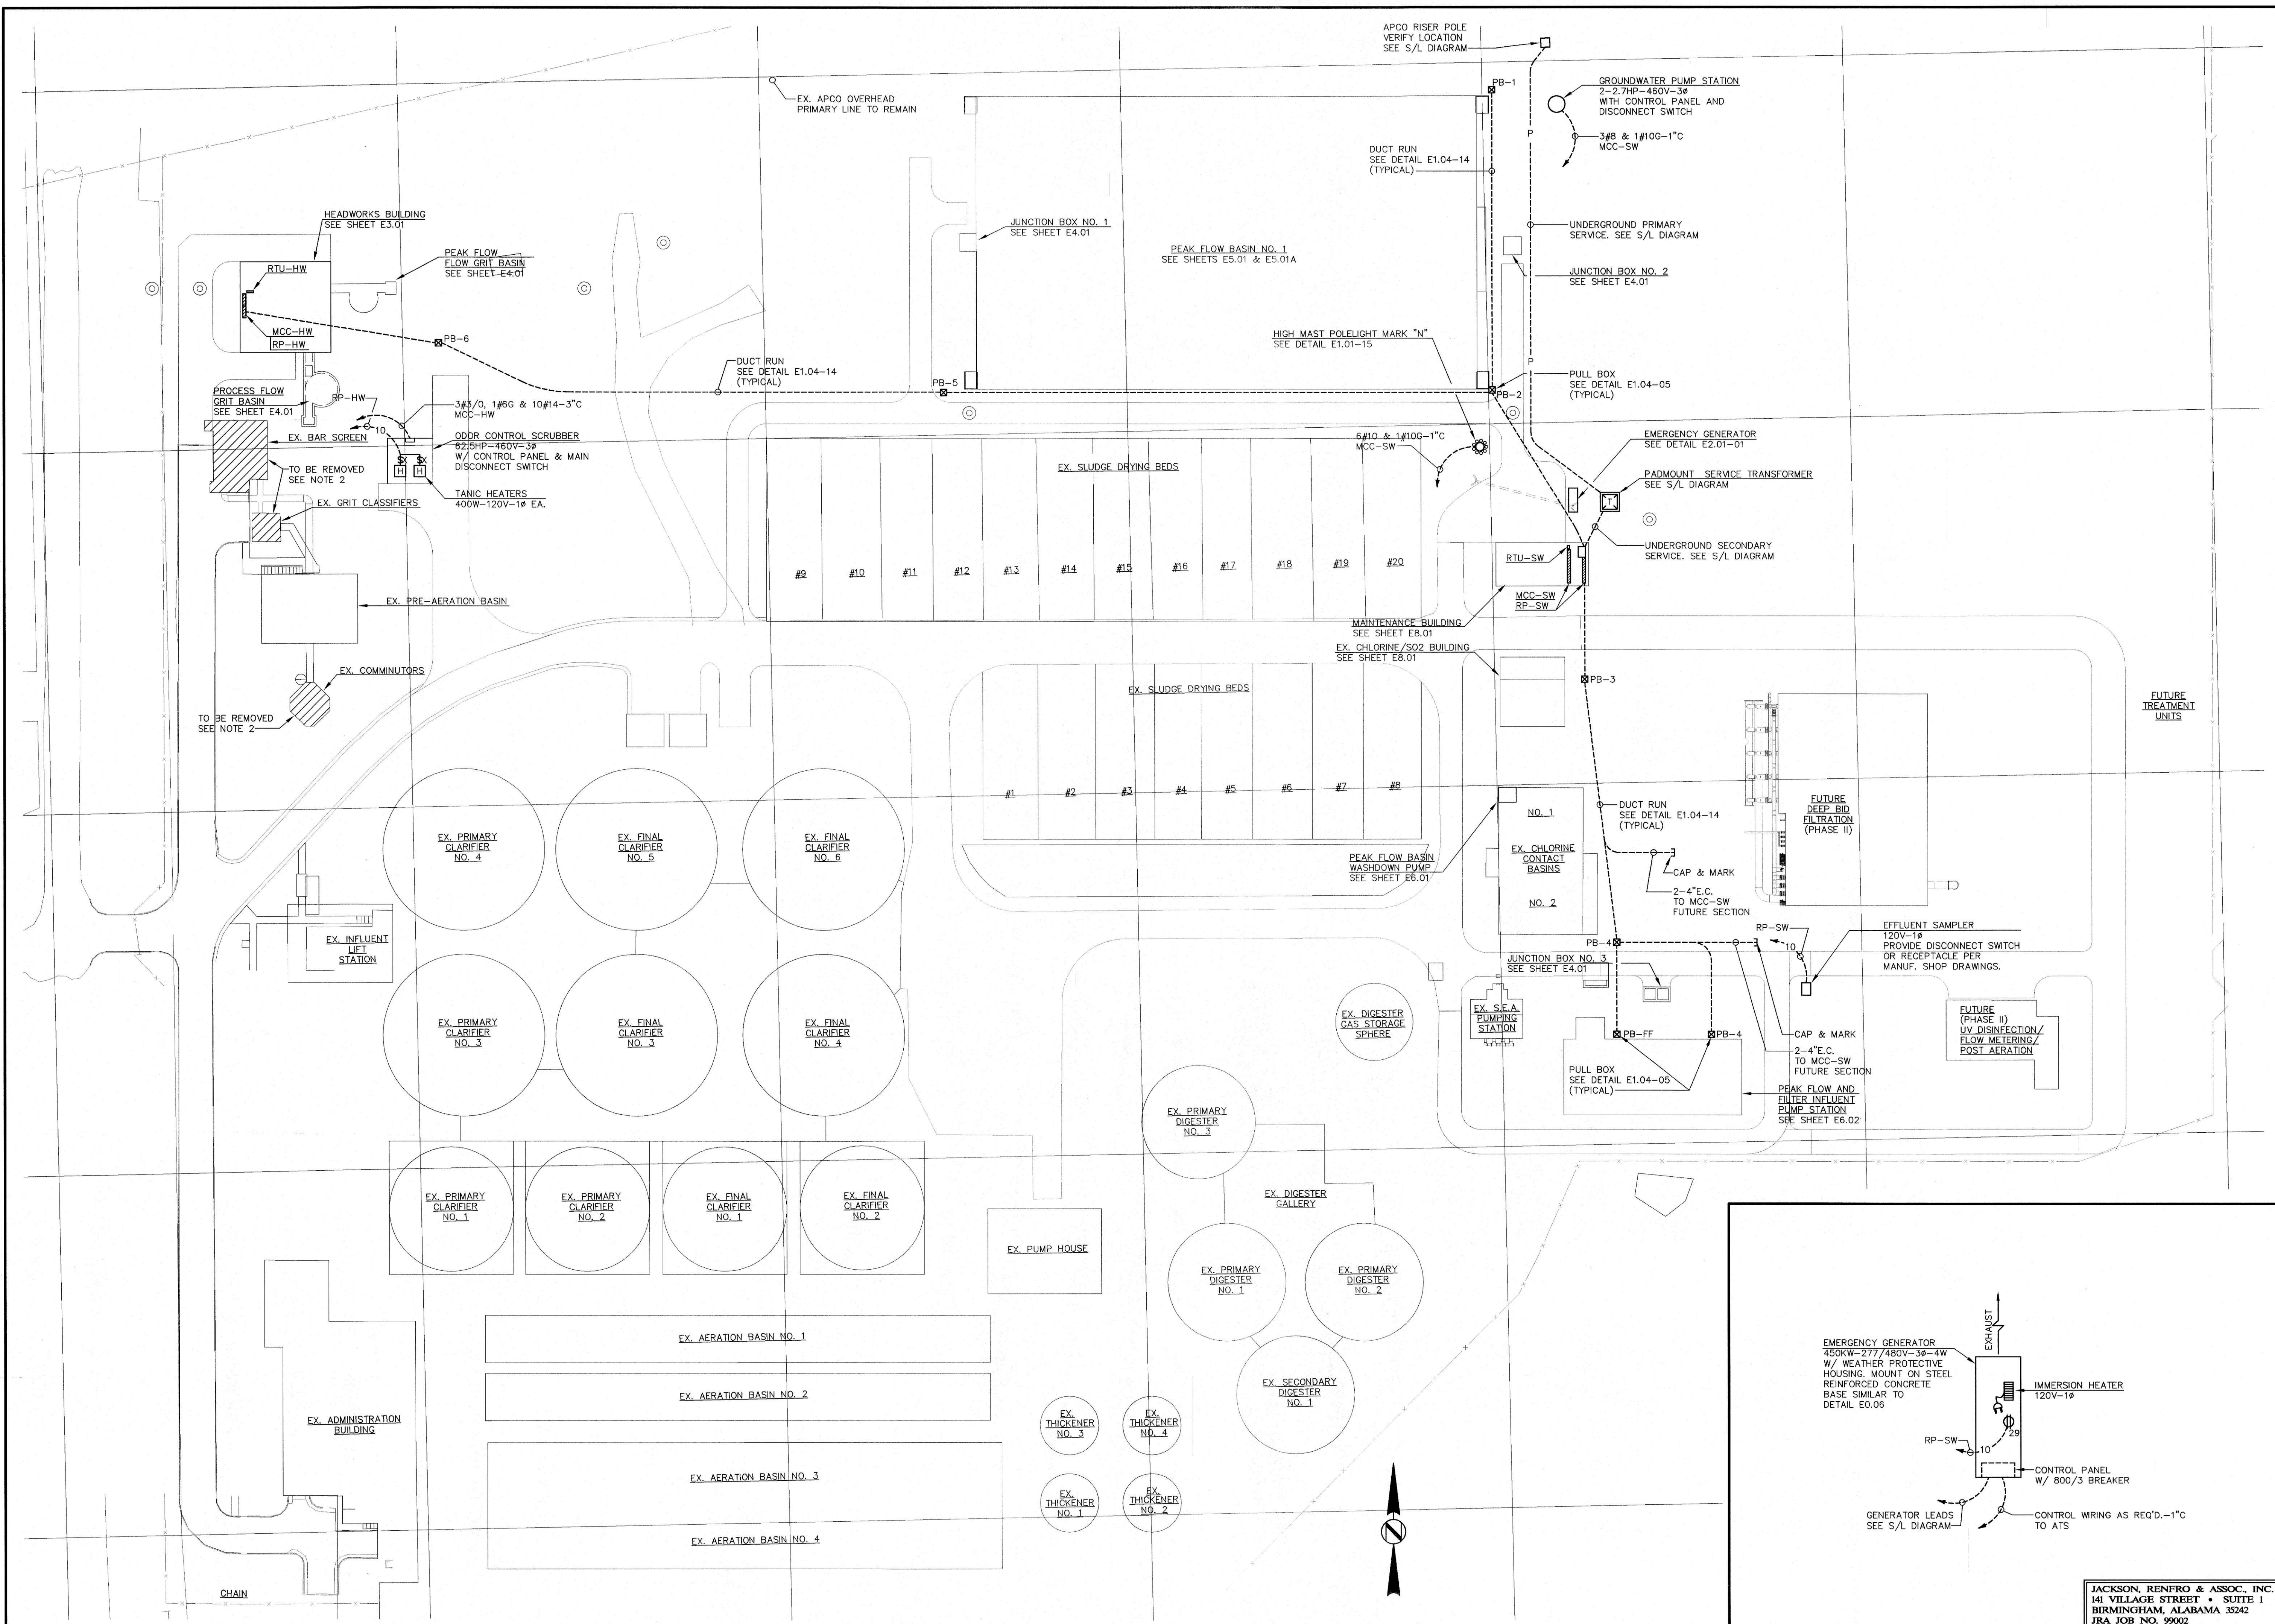

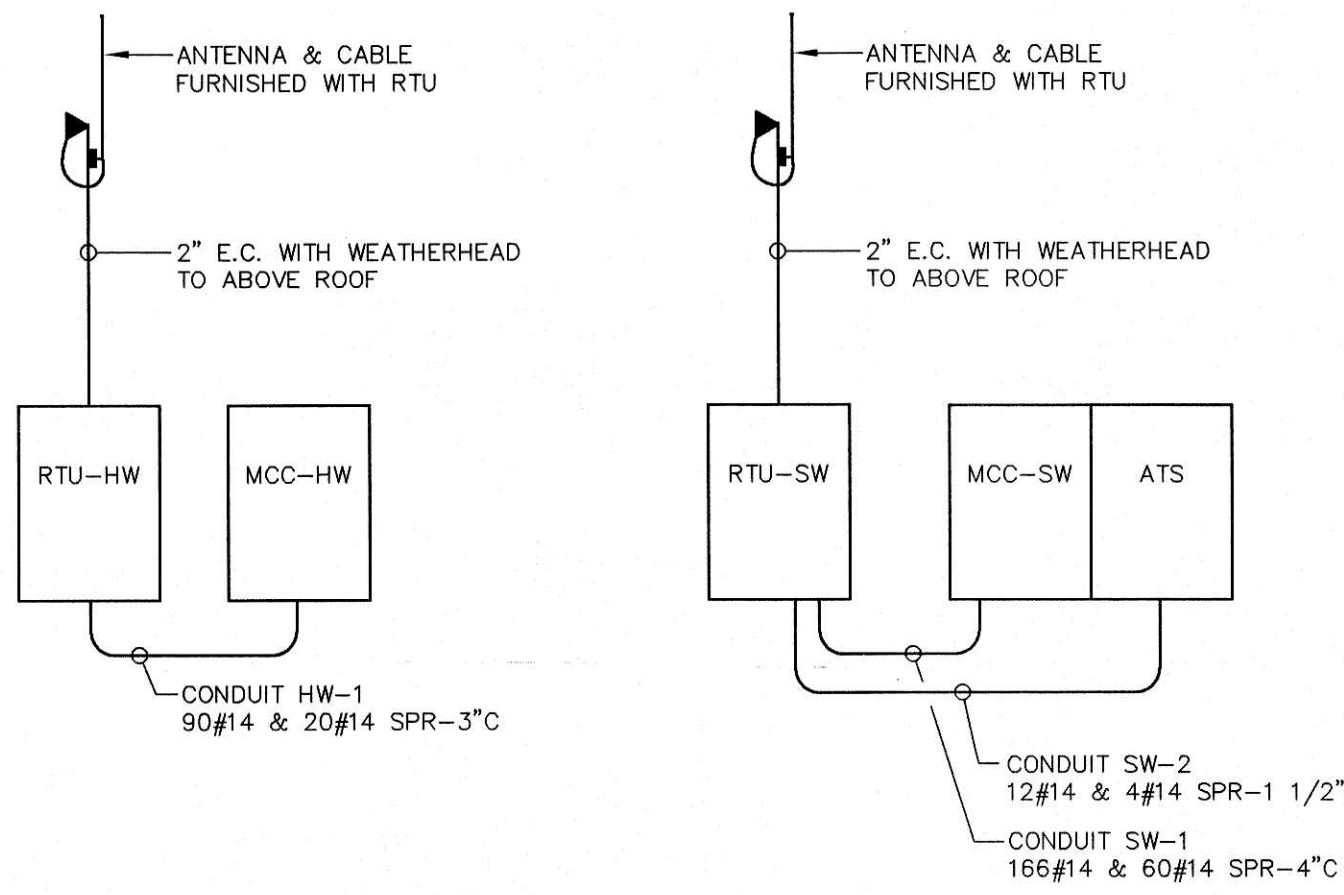

20 SCADA SYSTEM WIRING DIAGRAM

SCALE : NONE

SCADA SYSTEM WIRING SCHEDULE								
EQUIPMENT	DESCRIPTION	TYPE	PREFIX	NO.	FROM	TO	WIRE	CONDUIT
AUGER MONSTER NO.1	HOA SWITCH POSITION	DI	HW	101P	C.P.	RTU-HW	2 #14	HW-1
	ON/OFF STATUS	DI	HW	101S	C.P.	RTU-HW	2 #14	HW-1
	ON/OFF CONTROL	DO	HW	101C	C.P.	RTU-HW	2 #14	HW-1
	ALARM	DI	HW	101A	C.P.	RTU-HW	2 #14	HW-1
AUGER MONSTER NO.2	HOA SWITCH POSITION	DI	HW	102P	C.P.	RTU-HW	2 #14	HW-1
	ON/OFF STATUS	DI	HW	102S	C.P.	RTU-HW	2 #14	HW-1
	ON/OFF CONTROL	DO	HW	102C	C.P.	RTU-HW	2 #14	HW-1
	ALARM	DI	HW	102A	C.P.	RTU-HW	2 #14	HW-1
GRIT CLASSIFIER NO.1	HOA SWITCH POSITION	DI	HW	201P	MCC-HW	RTU-HW	2 #14	HW-1
	ON/OFF STATUS	DI	HW	201S	MCC-HW	RTU-HW	2 #14	HW-1
	ON/OFF CONTROL	DO	HW	201C	MCC-HW	RTU-HW	2 #14	HW-1
	ALARM	DI	HW	201A	MCC-HW	RTU-HW	2 #14	HW-1
GRIT CLASSIFIER NO.2	HOA SWITCH POSITION	DI	HW	202P	MCC-HW	RTU-HW	2 #14	HW-1
	ON/OFF STATUS	DI	HW	202S	MCC-HW	RTU-HW	2 #14	HW-1
	ON/OFF CONTROL	DO	HW	202C	MCC-HW	RTU-HW	2 #14	HW-1
	ALARM	DI	HW	202A	MCC-HW	RTU-HW	2 #14	HW-1
PEAK FLOW GRIT DRIVE	HOA SWITCH POSITION	DI	HW	301P	MCC-HW	RTU-HW	2 #14	HW-1
	ON/OFF STATUS	DI	HW	301S	MCC-HW	RTU-HW	2 #14	HW-1
	ON/OFF CONTROL	DO	HW	301C	MCC-HW	RTU-HW	2 #14	HW-1
	ALARM	DI	HW	301A	MCC-HW	RTU-HW	2 #14	HW-1
PROCESS FLOW GRIT DRIVE	HOA SWITCH POSITION	DI	HW	302P	MCC-HW	RTU-HW	2 #14	HW-1
	ON/OFF STATUS	DI	HW	302S	MCC-HW	RTU-HW	2 #14	HW-1
	ON/OFF CONTROL	DO	HW	302C	MCC-HW	RTU-HW	2 #14	HW-1
	ALARM	DI	HW	302A	MCC-HW	RTU-HW	2 #14	HW-1
BLOWER NO.1	HOA SWITCH POSITION	DI	HW	401P	MCC-HW	RTU-HW	2 #14	HW-1
	ON/OFF STATUS	DI	HW	401S	MCC-HW	RTU-HW	2 #14	HW-1
	ON/OFF CONTROL	DO	HW	401C	MCC-HW	RTU-HW	2 #14	HW-1
	ALARM	DI	HW	401A	MCC-HW	RTU-HW	2 #14	HW-1
BLOWER NO.2	HOA SWITCH POSITION	DI	HW	402P	MCC-HW	RTU-HW	2 #14	HW-1
	ON/OFF STATUS	DI	HW	402S	MCC-HW	RTU-HW	2 #14	HW-1
	ON/OFF CONTROL	DO	HW	402C	MCC-HW	RTU-HW	2 #14	HW-1
	ALARM	DI	HW	402A	MCC-HW	RTU-HW	2 #14	HW-1
BLOWER NO.3	HOA SWITCH POSITION	DI	HW	403P	MCC-HW	RTU-HW	2 #14	HW-1
	ON/OFF STATUS	DI	HW	403S	MCC-HW	RTU-HW	2 #14	HW-1
	ON/OFF CONTROL	DO	HW	403C	MCC-HW	RTU-HW	2 #14	HW-1
	ALARM	DI	HW	403A	MCC-HW	RTU-HW	2 #14	HW-1
ODOR CONTROL SCRUBBER	ON/OFF STATUS	DI	HW	600S	C.P.	RTU-HW	2 #14	HW-1
	ALARM	DI	HW	600A	C.P.	RTU-HW	2 #14	HW-1
PEAK FLOW WEIR GATE	HOA SWITCH POSITION	DI	HW	700P	C.P.	RTU-HW	2 #14	HW-1
	POSITION CONTROL	AO	HW	700PC	C.P.	RTU-HW	1 PR #16 SHD.	3/4" C
PROCESS FLOW WEIR GATE	HOA SWITCH POSITION	DI	HW	701P	C.P.	RTU-HW	2 #14	HW-1
	POSITION CONTROL	AO	HW	701PC	C.P.	RTU-HW	1 PR #16 SHD.	3/4" C
PEAK FLOW LEVEL TRANSMITTER	LEVEL	AI	HW	800L	XMTR.	RTU-HW	1 PR #16 SHD.	3/4" C
AERATOR NO. 1-1	HOA SWITCH POSITION	DI	SW	101P	MCC-SW	RTU-SW	2 #14	SW-1
	ON/OFF STATUS	DI	SW	101S	MCC-SW	RTU-SW	2 #14	SW-1
	ON/OFF CONTROL	DO	SW	101C	MCC-SW	RTU-SW	2 #14	SW-1
	ALARM	DI	SW	101A	MCC-SW	RTU-SW	2 #14	SW-1
AERATOR NO. 1-2	HOA SWITCH POSITION	DI	SW	102P	MCC-SW	RTU-SW	2 #14	SW-1
	ON/OFF STATUS	DI	SW	102S	MCC-SW	RTU-SW	2 #14	SW-1
	ON/OFF CONTROL	DO	SW	102C	MCC-SW	RTU-SW	2 #14	SW-1
	ALARM	DI	SW	102A	MCC-SW	RTU-SW	2 #14	SW-1
AERATOR NO. 1-3	HOA SWITCH POSITION	DI	SW	103P	MCC-SW	RTU-SW	2 #14	SW-1
	ON/OFF STATUS	DI	SW	103S	MCC-SW	RTU-SW	2 #14	SW-1
	ON/OFF CONTROL	DO	SW	103C	MCC-SW	RTU-SW	2 #14	SW-1
	ALARM	DI	SW	103A	MCC-SW	RTU-SW	2 #14	SW-1
AERATOR NO. 1-4	HOA SWITCH POSITION	DI	SW	104P	MCC-SW	RTU-SW	2 #14	SW-1
	ON/OFF STATUS	DI	SW	104S	MCC-SW	RTU-SW	2 #14	SW-1
	ON/OFF CONTROL	DO	SW	104C	MCC-SW	RTU-SW	2 #14	SW-1
	ALARM	DI	SW	104A	MCC-SW	RTU-SW	2 #14	SW-1
AERATOR NO. 1-5	HOA SWITCH POSITION	DI	SW	105P	MCC-SW	RTU-SW	2 #14	SW-1
	ON/OFF STATUS	DI	SW	105S	MCC-SW	RTU-SW	2 #14	SW-1
	ON/OFF CONTROL	DO	SW	105C	MCC-SW	RTU-SW	2 #14	SW-1
	ALARM	DI	SW	105A	MCC-SW	RTU-SW	2 #14	SW-1
AERATOR NO. 1-6	HOA SWITCH POSITION	DI	SW	106P	MCC-SW	RTU-SW	2 #14	SW-1
	ON/OFF STATUS	DI	SW	106S	MCC-SW	RTU-SW	2 #14	SW-1
	ON/OFF CONTROL	DO	SW	106C	MCC-SW	RTU-SW	2 #14	SW-1
	ALARM	DI	SW	106A	MCC-SW	RTU-SW	2 #14	SW-1
MIXER NO. 1-1	HOA SWITCH POSITION	DI	SW	111P	MCC-SW	RTU-SW	2 #14	SW-1
	ON/OFF STATUS	DI	SW	111S	MCC-SW	RTU-SW	2 #14	SW-1
	ON/OFF CONTROL	DO	SW	111C	MCC-SW	RTU-SW	2 #14	SW-1
	ALARM	DI	SW	111A	MCC-SW	RTU-SW	2 #14	SW-1
MIXER NO. 1-2	HOA SWITCH POSITION	DI	SW	112P	MCC-SW	RTU-SW	2 #14	SW-1
	ON/OFF STATUS	DI	SW	112S	MCC-SW	RTU-SW	2 #14	SW-1
	ON/OFF CONTROL	DO	SW	112C	MCC-SW	RTU-SW	2 #14	SW-1
	ALARM	DI	SW	112A	MCC-SW	RTU-SW	2 #14	SW-1

03 SCADA SYSTEM WIRING SCHEDULE


SCADA SYSTEM WIRING SCHEDULE (CONTINUED)								
EQUIPMENT	DESCRIPTION	TYPE	PREFIX	NO.	FROM	TO	WIRE	CONDUIT
PEAK FLOW BASIN NO.1	LEVEL LOW LEVEL CUT OFF	AI DI		SW100L SW100C	XMTR. MCC-SW	RTU-SW RTU-SW	1 PR #16 SHD. 2 #14	3/4" C SW-1
PEAK FLOW WASHDOWN PUMP	ON/OFF STATUS ALARM	DI DI		SW400S SW400A	MCC-SW MCC-SW	RTU-SW RTU-SW	2 #14 2 #14	SW-1 SW-1
PEAK FLOW PUMP NO.1	HOA SWITCH POSITION ON/OFF STATUS ALARM SPEED CONTROL	DI DI DI AO		SW501P SW501S SW501A SW501SC	MCC-SW MCC-SW MCC-SW MCC-SW	RTU-SW RTU-SW RTU-SW RTU-SW	2 #14 2 #14 2 #14 1 PR #16 SHD.	SW-1 SW-1 SW-1 3/4" C
PEAK FLOW PUMP NO.2	HOA SWITCH POSITION ON/OFF STATUS ALARM	DI DI DI		SW502P SW502S SW502A	MCC-SW MCC-SW MCC-SW	RTU-SW RTU-SW RTU-SW	2 #14 2 #14 2 #14	SW-1 SW-1 SW-1
PEAK FLOW PUMP NO.3	HOA SWITCH POSITION ON/OFF STATUS ALARM	DI DI DI		SW503P SW503S SW503A	MCC-SW MCC-SW MCC-SW	RTU-SW RTU-SW RTU-SW	2 #14 2 #14 2 #14	SW-1 SW-1 SW-1
PEAK FLOW PUMP STATION	LEVEL	AI		SW500L	C.P.	RTU-SW	1 PR #16 SHD.	1" C
PEAK FLOW TRANSMITTER	FLOW	AI		SW500F	C.P.	RTU-SW	1 PR #16 SHD.	
SEWAGE SHREDDER	HOA SWITCH POSITION ON/OFF STATUS ON/OFF CONTROL ALARM	DI DI DO DI		SW600P SW600S SW600C SW600A	C.P. C.P. C.P. C.P.	RTU-SW RTU-SW RTU-SW RTU-SW	2 #14 2 #14 2 #14 2 #14	SW-1 SW-1 SW-1 SW-1
SLUICE GATE NO.1-1	OPEN CONTROL OPEN STATUS CLOSE CONTROL CLOSE STATUS	DO DI DO DI		SW1210C SW1210S SW1210C SW1210S	C.P. C.P. C.P. C.P.	RTU-SW RTU-SW RTU-SW RTU-SW	2 #14 2 #14 2 #14 2 #14	SW-1 SW-1 SW-1 SW-1
SLUICE GATE NO.1-2	OPEN CONTROL OPEN STATUS CLOSE CONTROL CLOSE STATUS	DO DI DO DI		SW1220C SW1220S SW1220C SW1220S	C.P. C.P. C.P. C.P.	RTU-SW RTU-SW RTU-SW RTU-SW	2 #14 2 #14 2 #14 2 #14	SW-1 SW-1 SW-1 SW-1
SLUICE GATE NO.2-1	OPEN CONTROL OPEN STATUS CLOSE CONTROL CLOSE STATUS	DO DI DO DI		SW2210C SW2210S SW2210C SW2210S	C.P. C.P. C.P. C.P.	RTU-SW RTU-SW RTU-SW RTU-SW	2 #14 2 #14 2 #14 2 #14	SW-1 SW-1 SW-1 SW-1
SLUICE GATE NO.2-2	OPEN CONTROL OPEN STATUS CLOSE CONTROL CLOSE STATUS	DO DI DO DI		SW2220C SW2220S SW2220C SW2220S	C.P. C.P. C.P. C.P.	RTU-SW RTU-SW RTU-SW RTU-SW	2 #14 2 #14 2 #14 2 #14	SW-1 SW-1 SW-1 SW-1
SLUICE GATE NO.3-1	OPEN CONTROL OPEN STATUS CLOSE CONTROL CLOSE STATUS	DO DI DO DI		SW3210C SW3210S SW3210C SW3210S	C.P. C.P. C.P. C.P.	RTU-SW RTU-SW RTU-SW RTU-SW	2 #14 2 #14 2 #14 2 #14	SW-1 SW-1 SW-1 SW-1
SLUICE GATE NO.3-2	OPEN CONTROL OPEN STATUS CLOSE CONTROL CLOSE STATUS	DO DI DO DI		SW3220C SW3220S SW3220C SW3220S	C.P. C.P. C.P. C.P.	RTU-SW RTU-SW RTU-SW RTU-SW	2 #14 2 #14 2 #14 2 #14	SW-1 SW-1 SW-1 SW-1
EMERGENCY GENERATOR	ON/OFF STATUS NORMAL POWER AVAILABLE EMERGENCY POWER AVAILABLE TRANSFER SWITCH POSITION MINOR ALARM MAJOR ALARM GENERATOR KW	DI DI DI DI DI DI AI		SW600S SW600NA SW600EA SW600P SW600A SW600P SW600KW	ATS ATS ATS ATS ATS ATS ATS	RTU-SW RTU-SW RTU-SW RTU-SW RTU-SW RTU-SW RTU-SW	2 #14 2 #14 2 #14 2 #14 2 #14 2 #14 1 PR #16 SHD.	SW-2 SW-2 SW-2 SW-2 SW-2 SW-2 3/4" C
HIGH MAST LIGHTING LEVEL 1	HOA SWITCH POSITION ON/OFF STATUS ON/OFF CONTROL	DI DI DO		SW701P SW701S SW701C	MCC-SW MCC-SW MCC-SW	RTU-SW RTU-SW RTU-SW	2 #14 2 #14 2 #14	SW-1 SW-1 SW-1
HIGH MAST LIGHTING LEVEL 2	HOA SWITCH POSITION ON/OFF STATUS ON/OFF CONTROL	DI DI DO		SW702P SW702S SW702C	MCC-SW MCC-SW MCC-SW	RTU-SW RTU-SW RTU-SW	2 #14 2 #14 2 #14	SW-1 SW-1 SW-1

JACKSON, RENFRO & ASSOC., INC.
141 VILLAGE STREET • SUITE 1
BIRMINGHAM, ALABAMA 35242
JRA JOB NO. 99002


SCALE : NONE

© 1999 PAUL B. KREBS & ASSOCIATES, INC.

KREBS
PAUL B. KREBS & ASSOCIATES, INC.
ARCHITECTS / ENGINEERS
BIRMINGHAM · ALBANY · MONTGOMERY

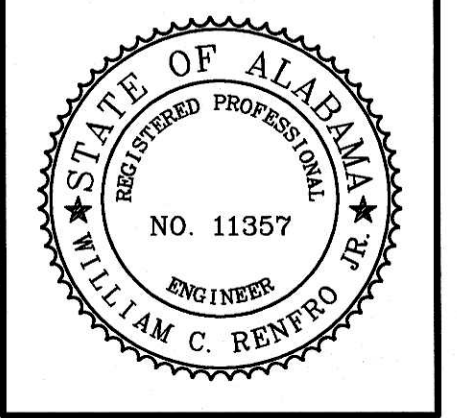


WATER WORKS & SEWER BOARD
CITY OF ANNISTON
CHOCOLOCO WWTP
IMPROVEMENTS
ANNISTON, ALABAMA

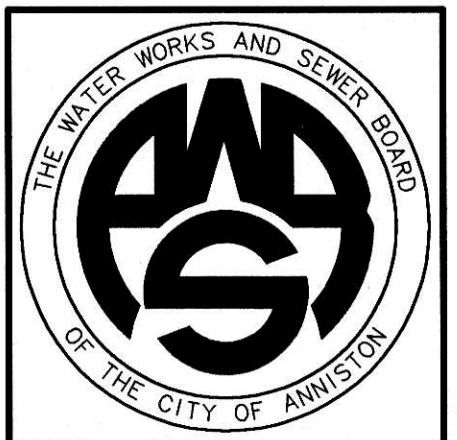


PROJECT NO.		98062
DESIGNED		WCR
DRAWN		CAB
CHECKED		WCR
APPROVED		
DATE		JULY 1999
REVISIONS		
N.O.	DATE	DESCRIPTION
1	11-17-06	RECORD DRAWING

RECORD
DRAWING


SHEET TITLE
SCADA SYSTEM WIRING
SCHEDULE & DETAIL
BASE BID
SHEET NO.
E1.05
SEQUENCE 76 OF 84

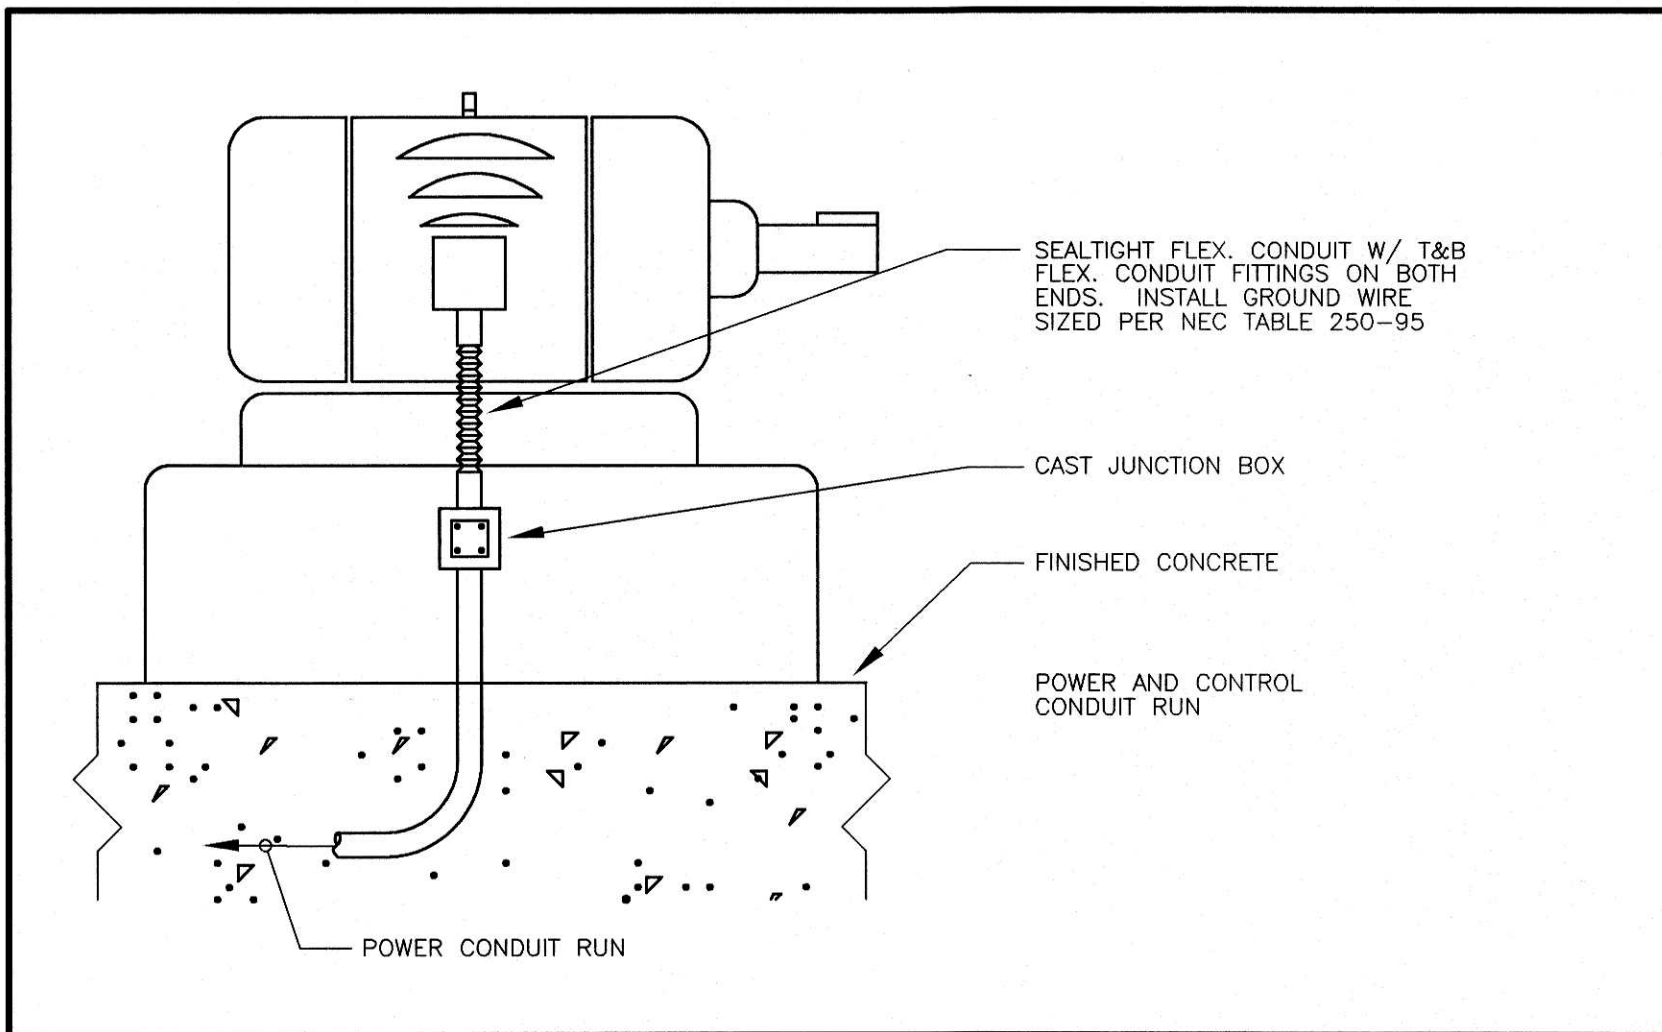


20 MOTOR FEEDER CONNECTION SCALE : NONE

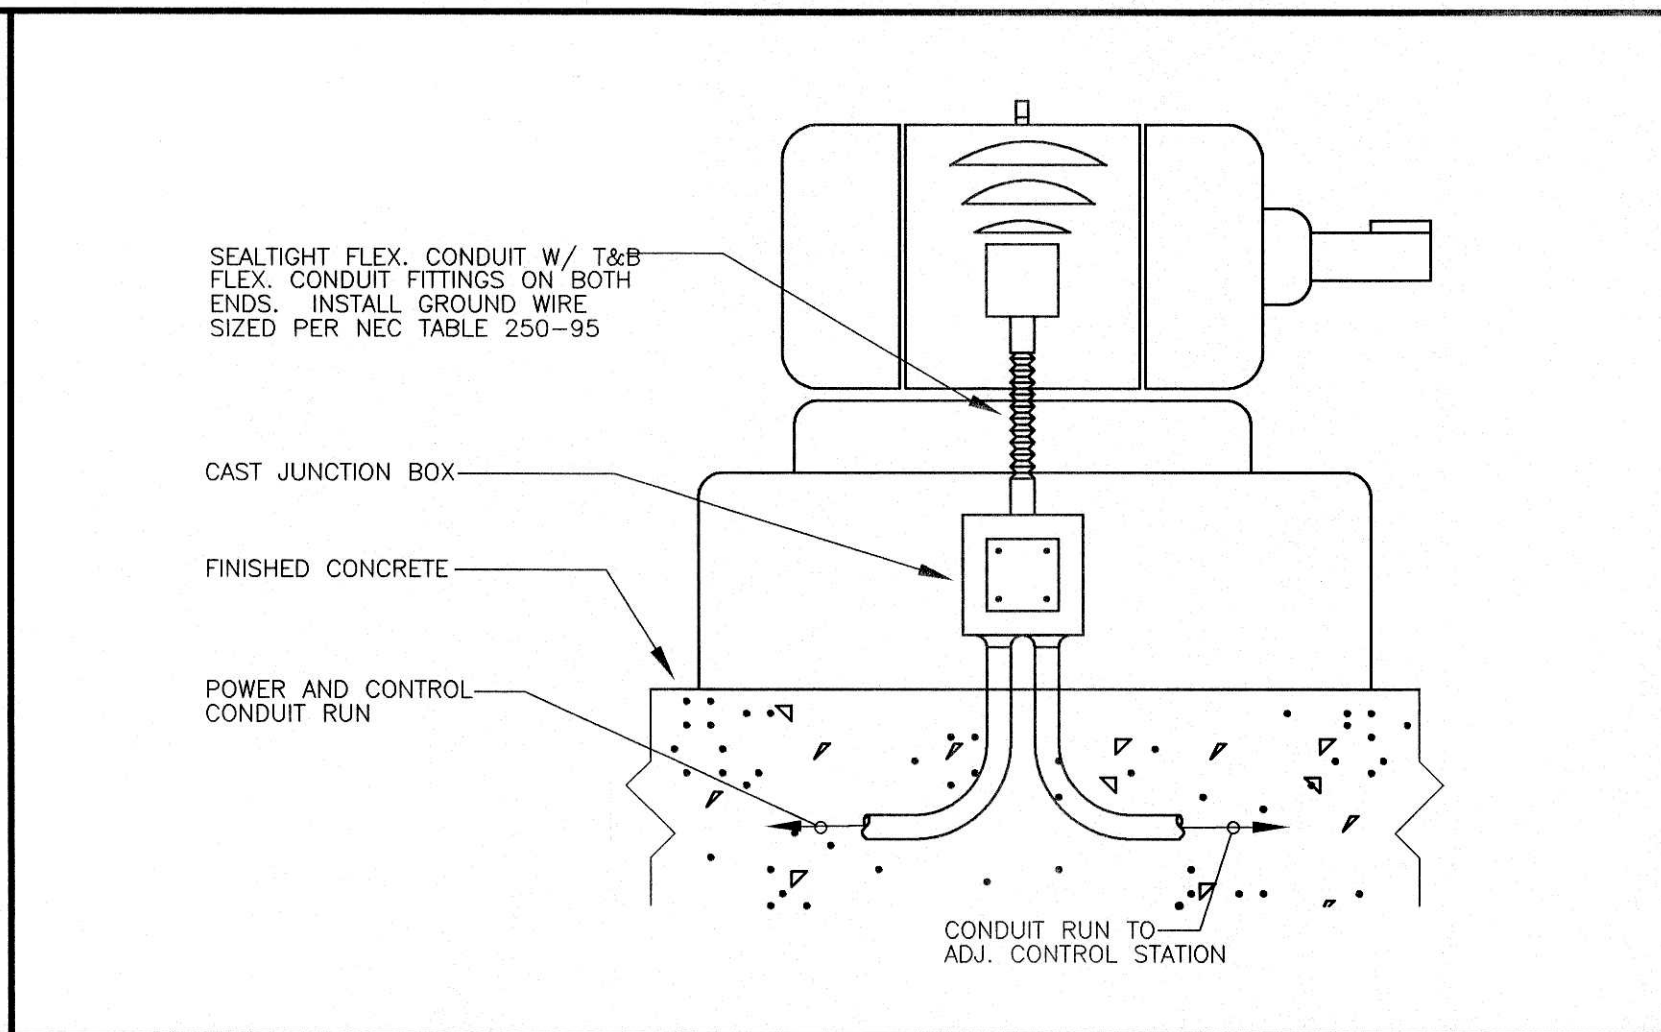


18 MOTOR CONNECTION W/ADJ. CONTR. STA. SCALE : NONE

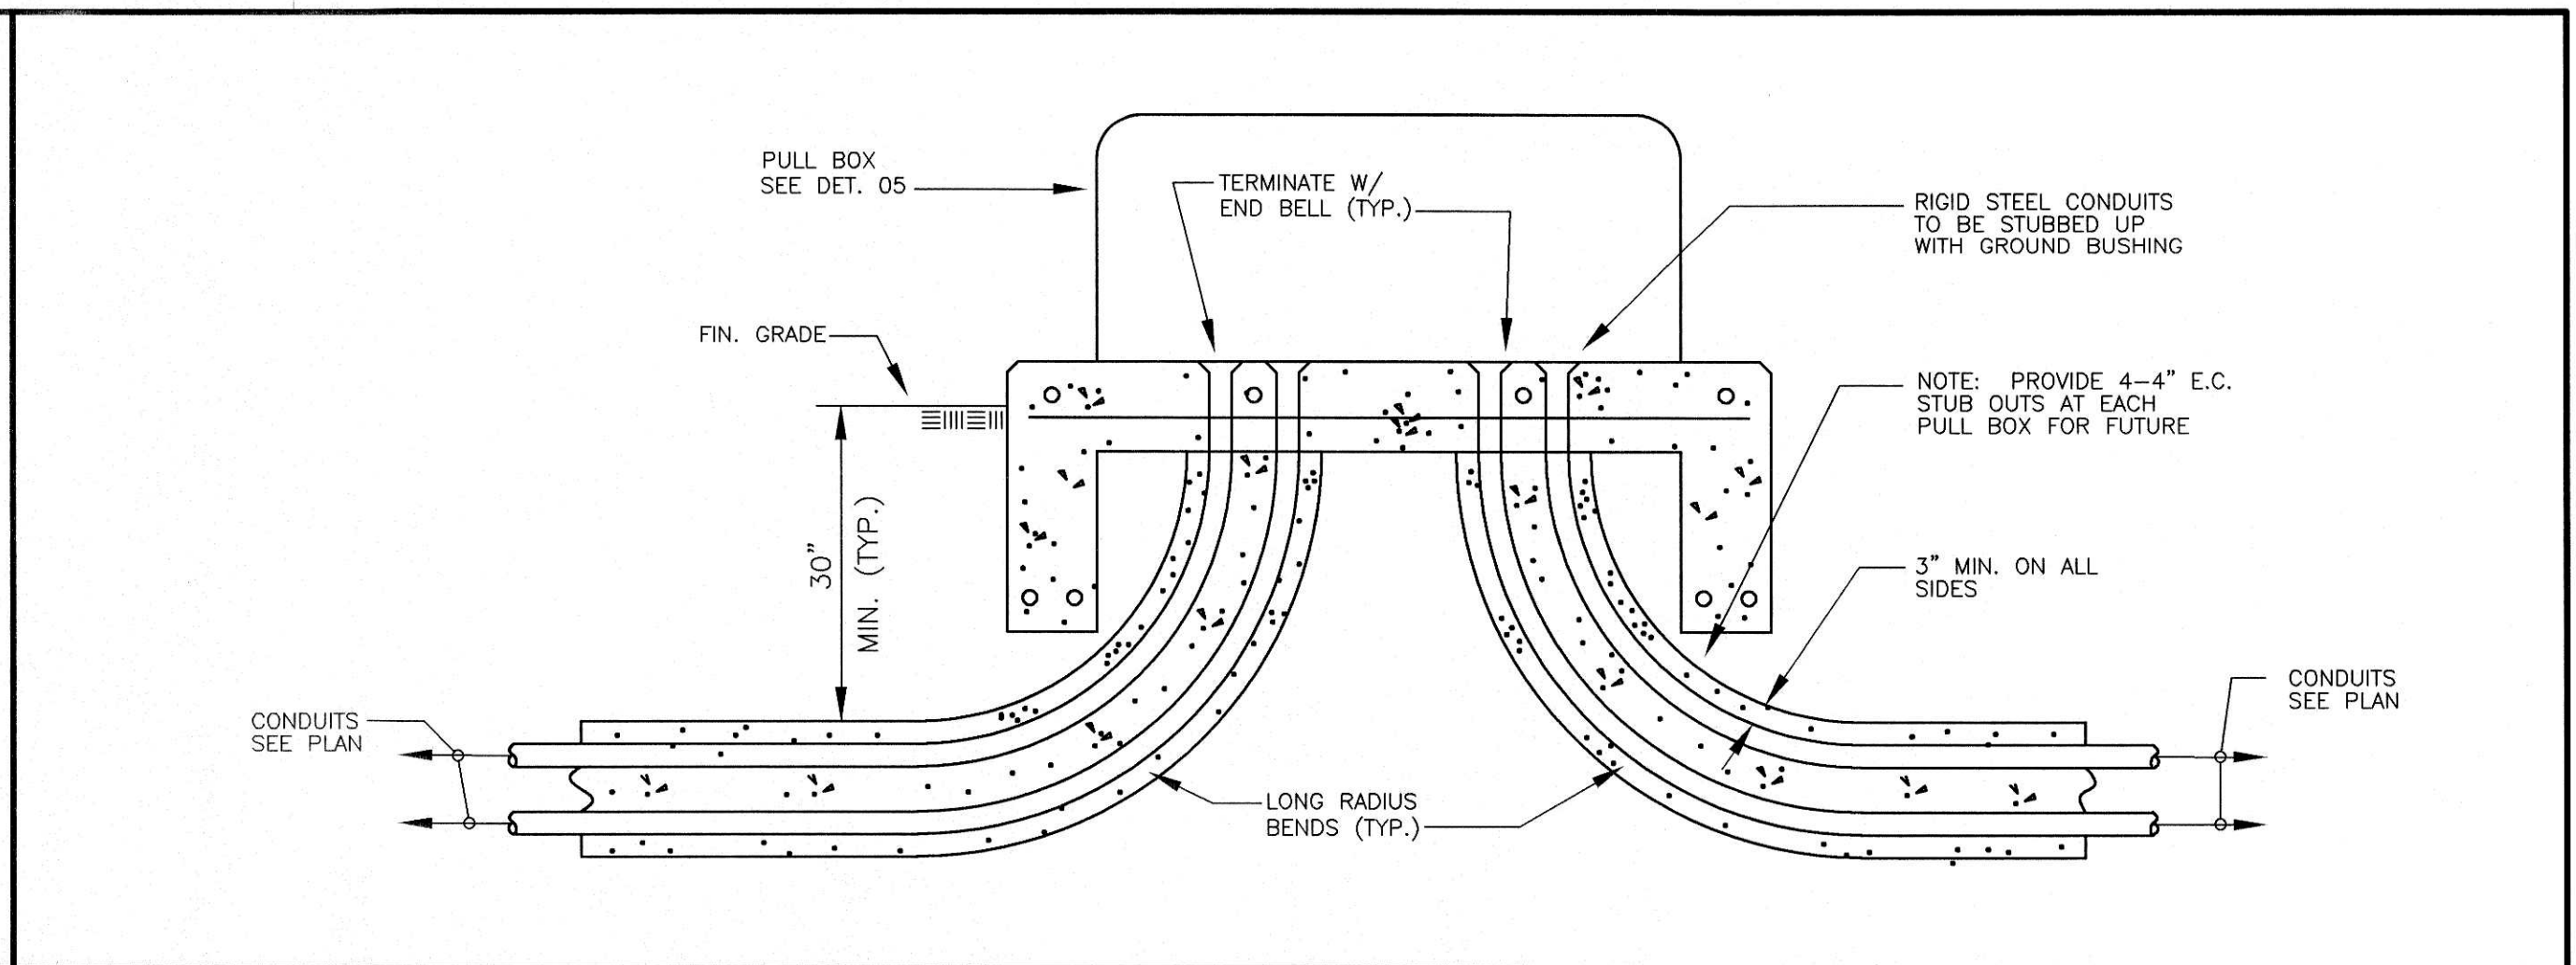


17 CONDUIT TERMINATION AT PULL BOX SCALE : NONE

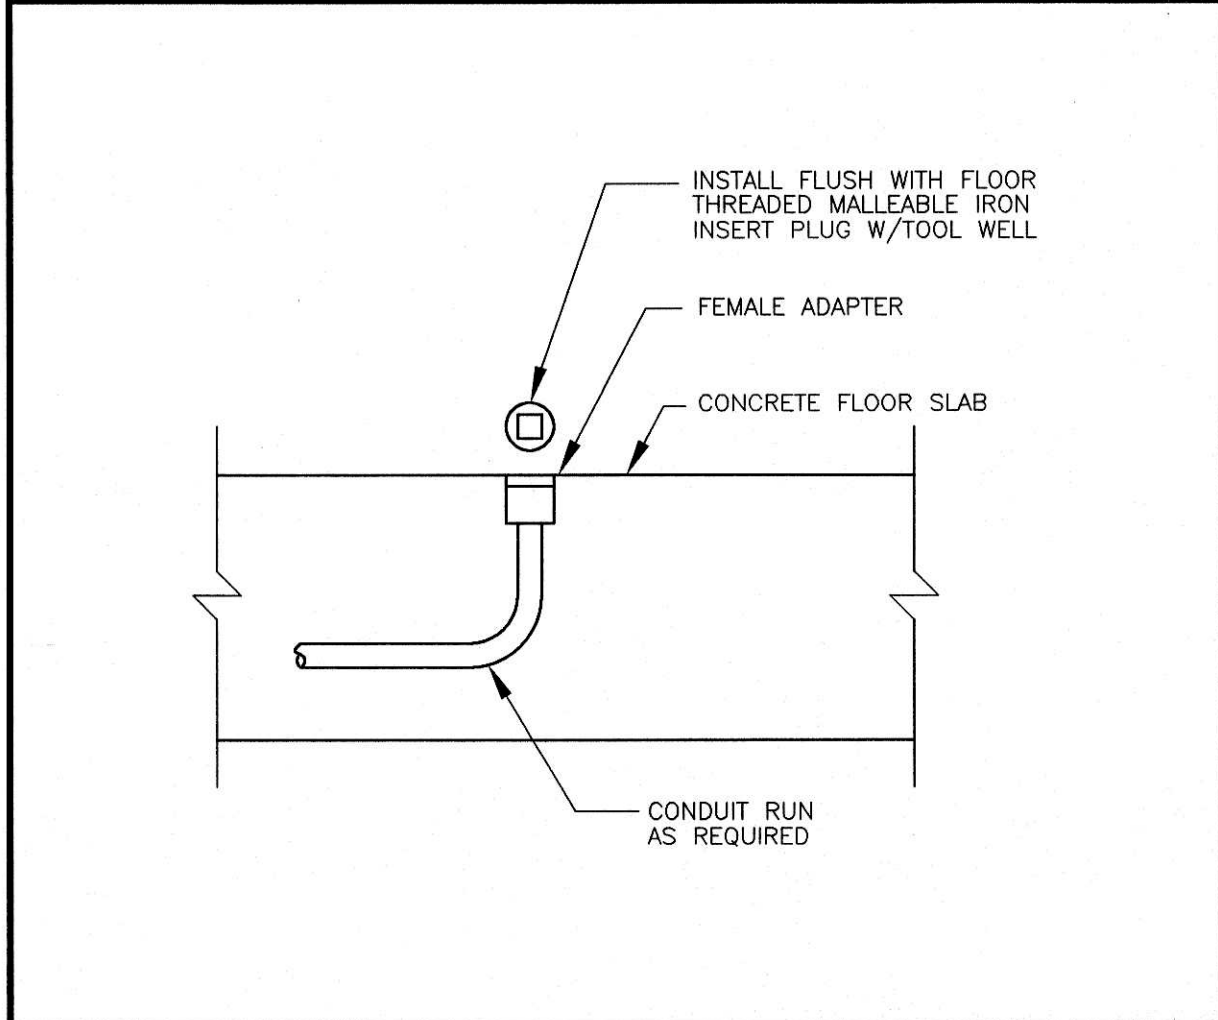


15 FUT. CONDUIT STUB-UP SCALE : NONE

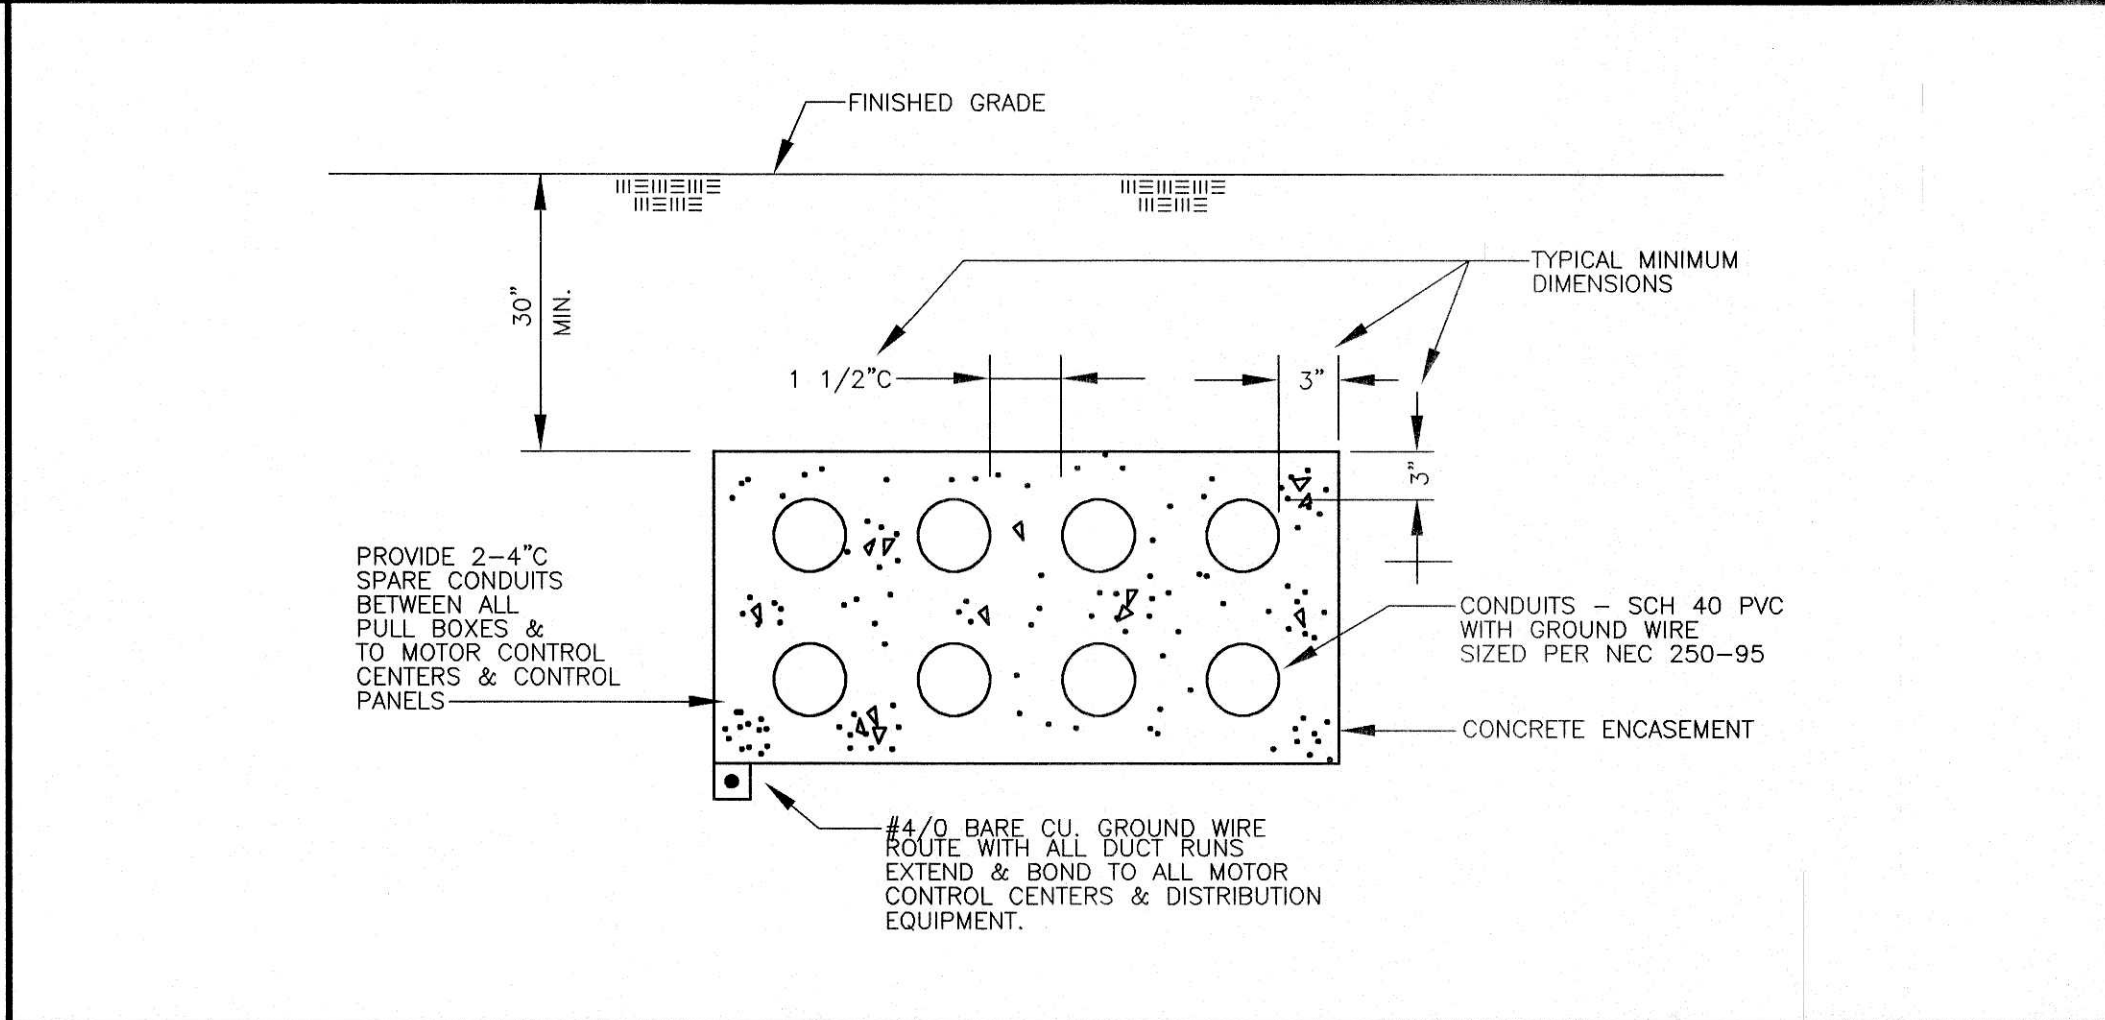

14 TYPICAL DUCT RUN SECTION SCALE : NONE

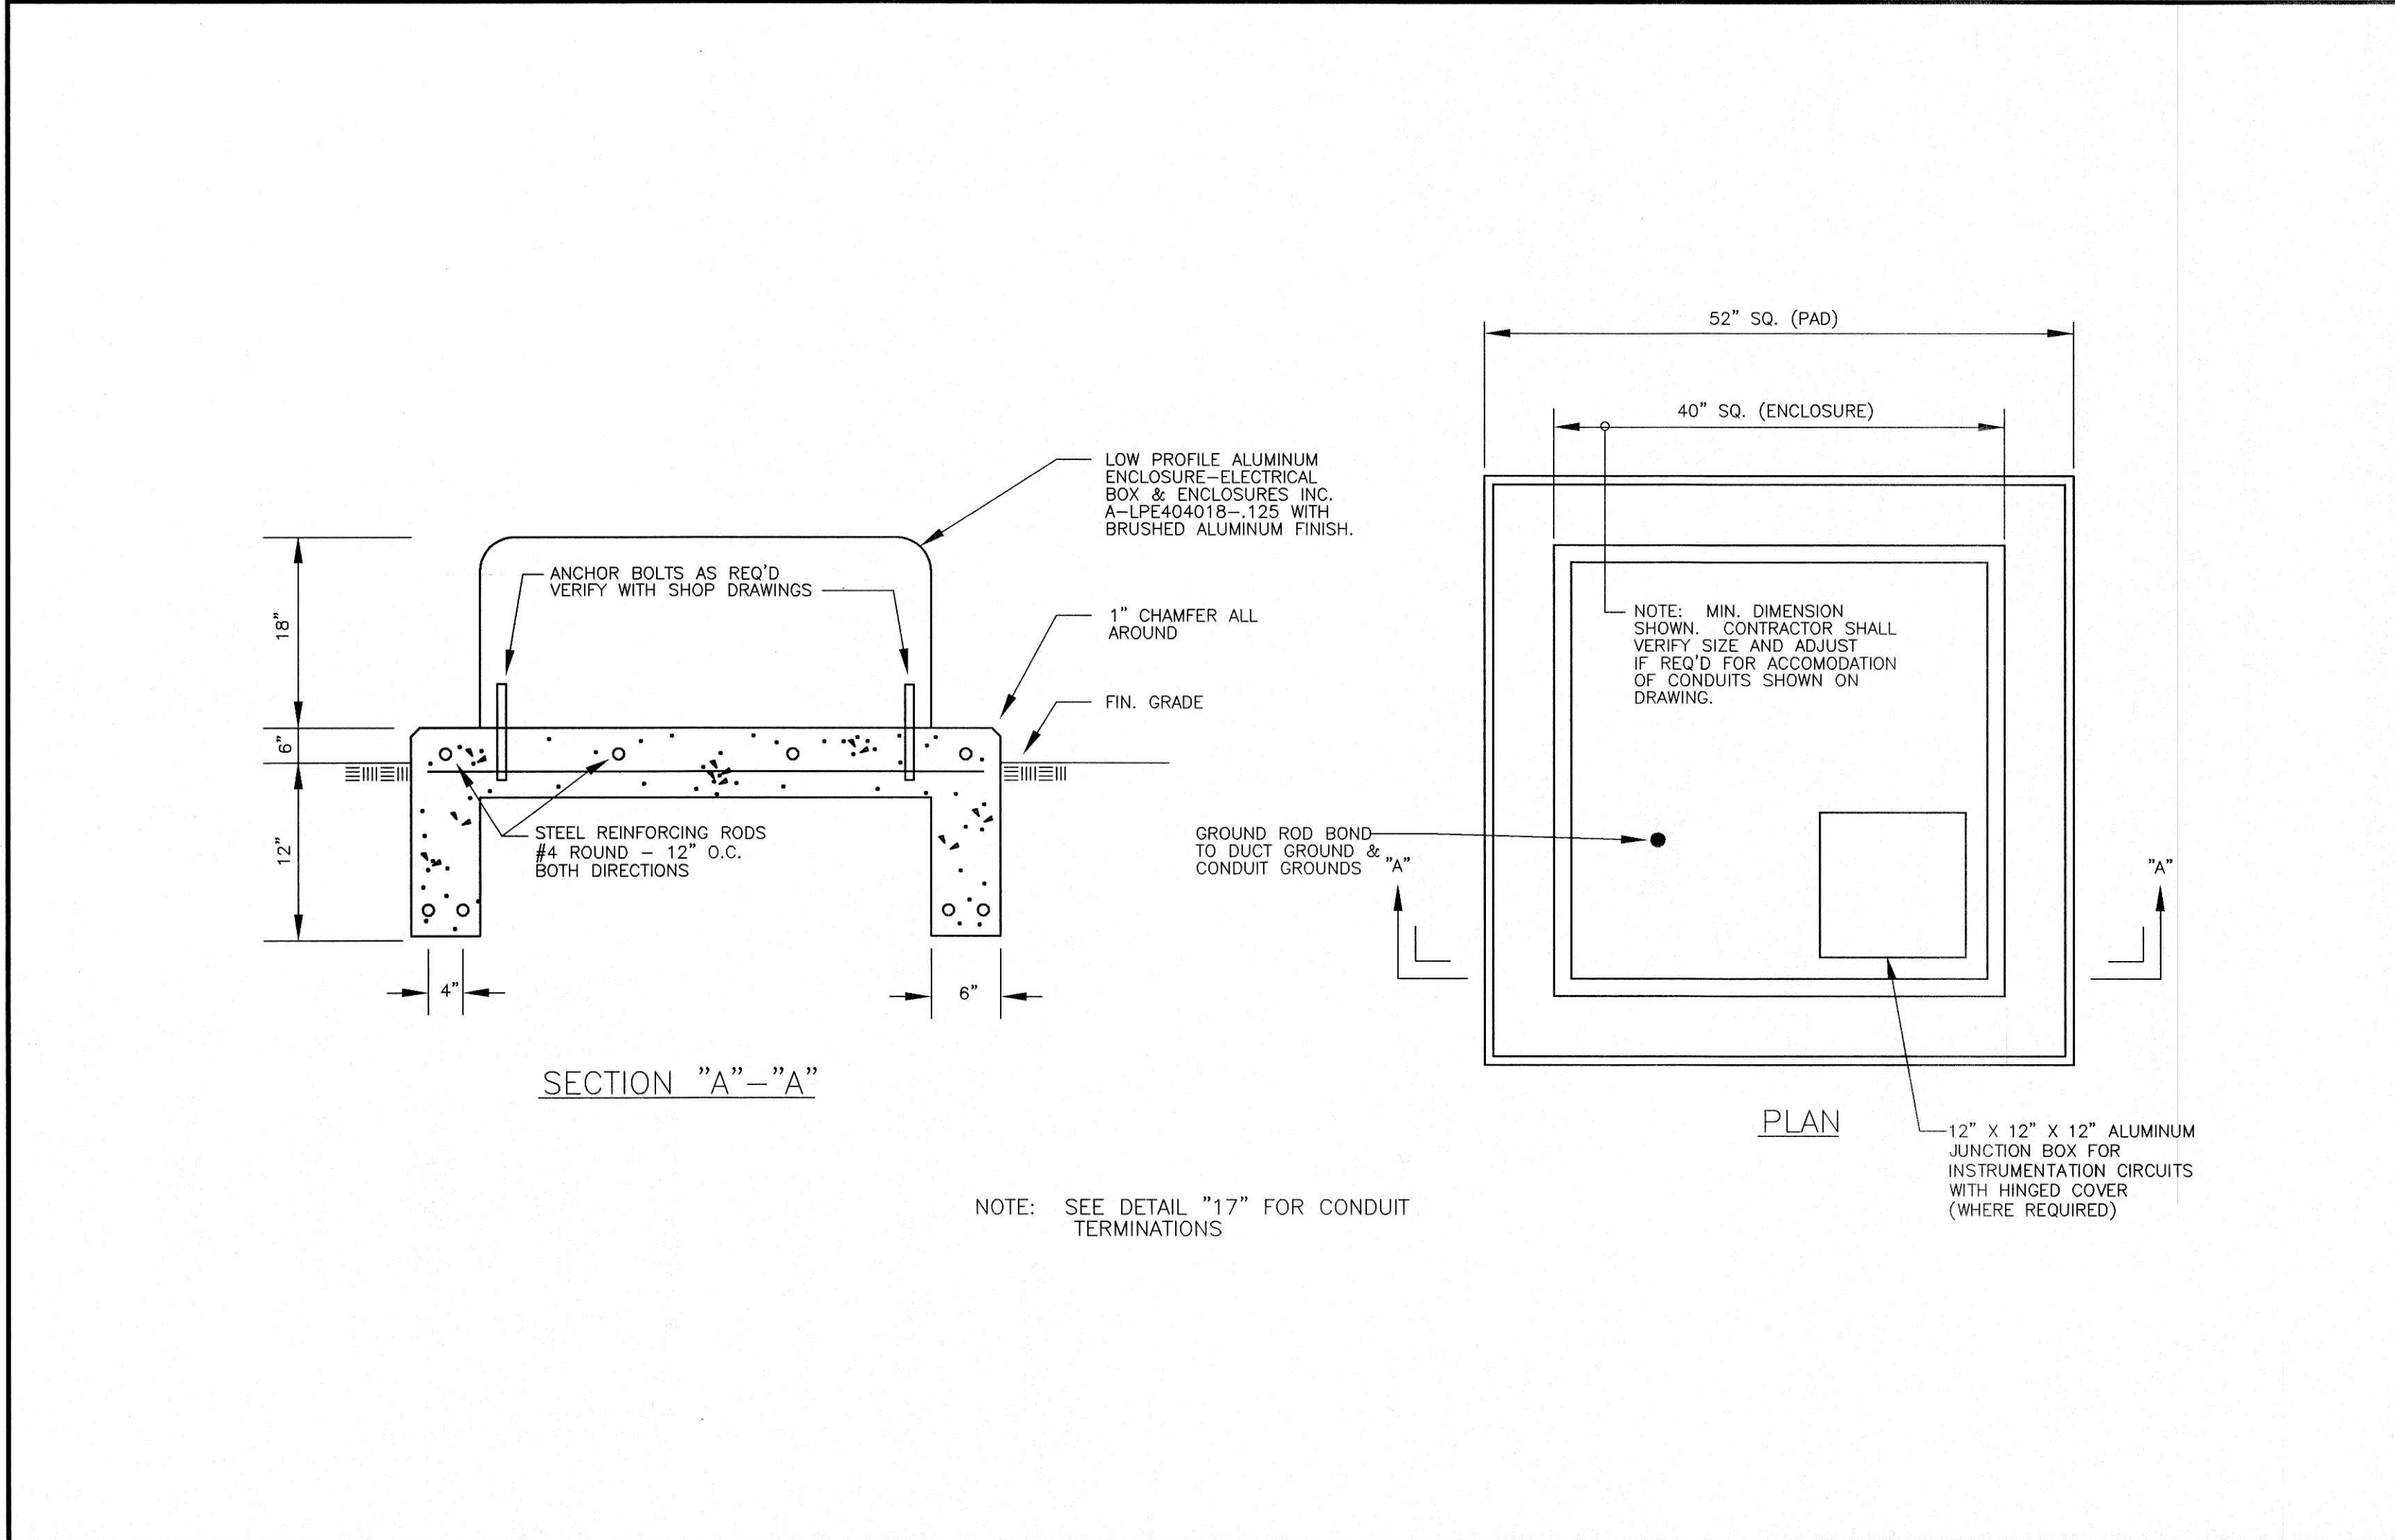


05 TYPICAL PULL BOX SCALE : NONE

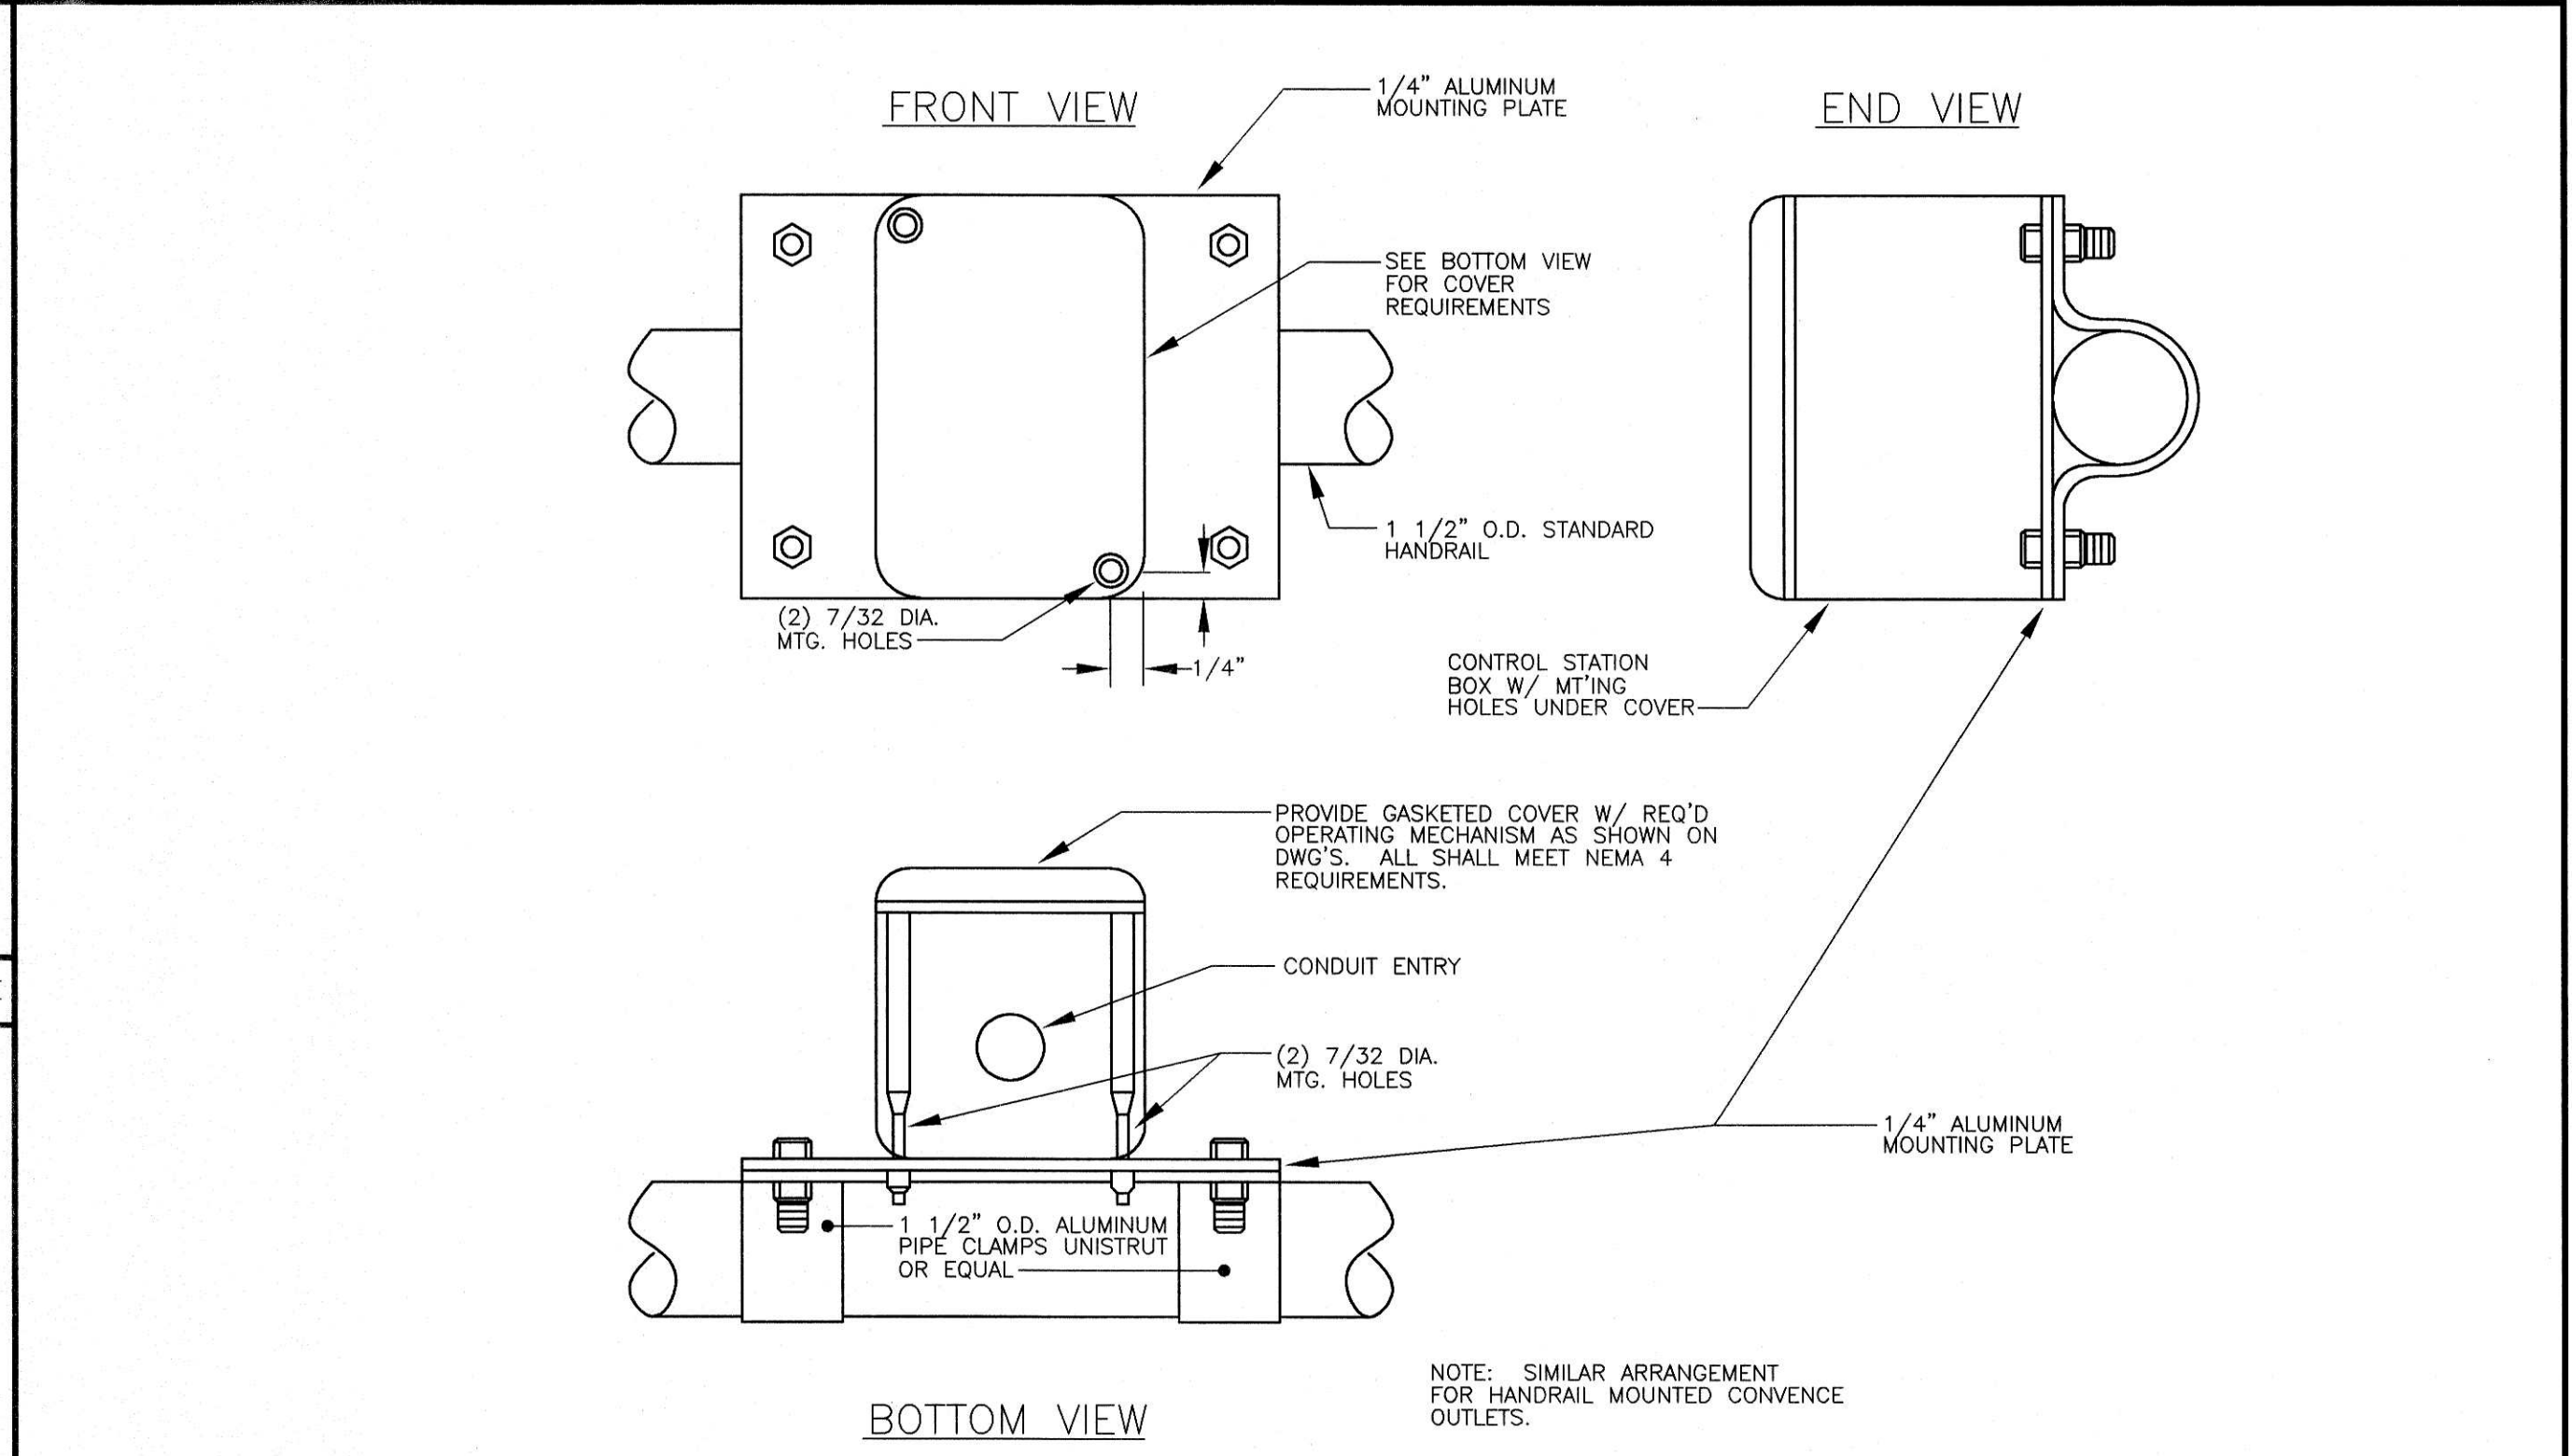


07 TYPICAL NEMA 4 CONTROL STATION HANDRAIL MOUNTING SCALE : NONE

JACKSON, RENFRO & ASSOC., INC.
141 VILLAGE STREET • SUITE 1
BIRMINGHAM, ALABAMA 35242
JRA JOB NO. 99002

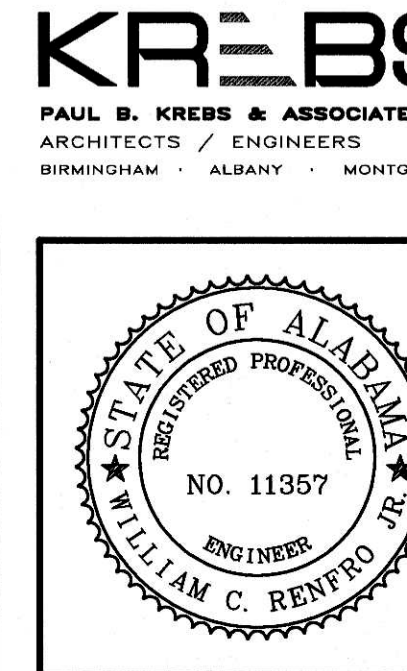

WATER WORKS & SEWER BOARD
CITY OF ANNISTON
CHOCOLOCOO WWTP
IMPROVEMENTS

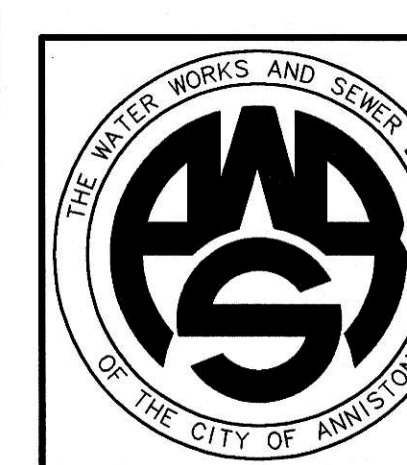


PROJECT NO.	98062	
DESIGNED	WCR	
DRAWN	CAB	
CHECKED	WCR	
APPROVED		
DATE	JULY 1999	
REVISIONS		
NO.	DATE	DESCRIPTION
1	11-17-06	RECORD DRAWING

RECORD
DRAWING


ELECTRICAL DETAILS

SHEET NO.
E1.04
SEQUENCE 75 OF 84

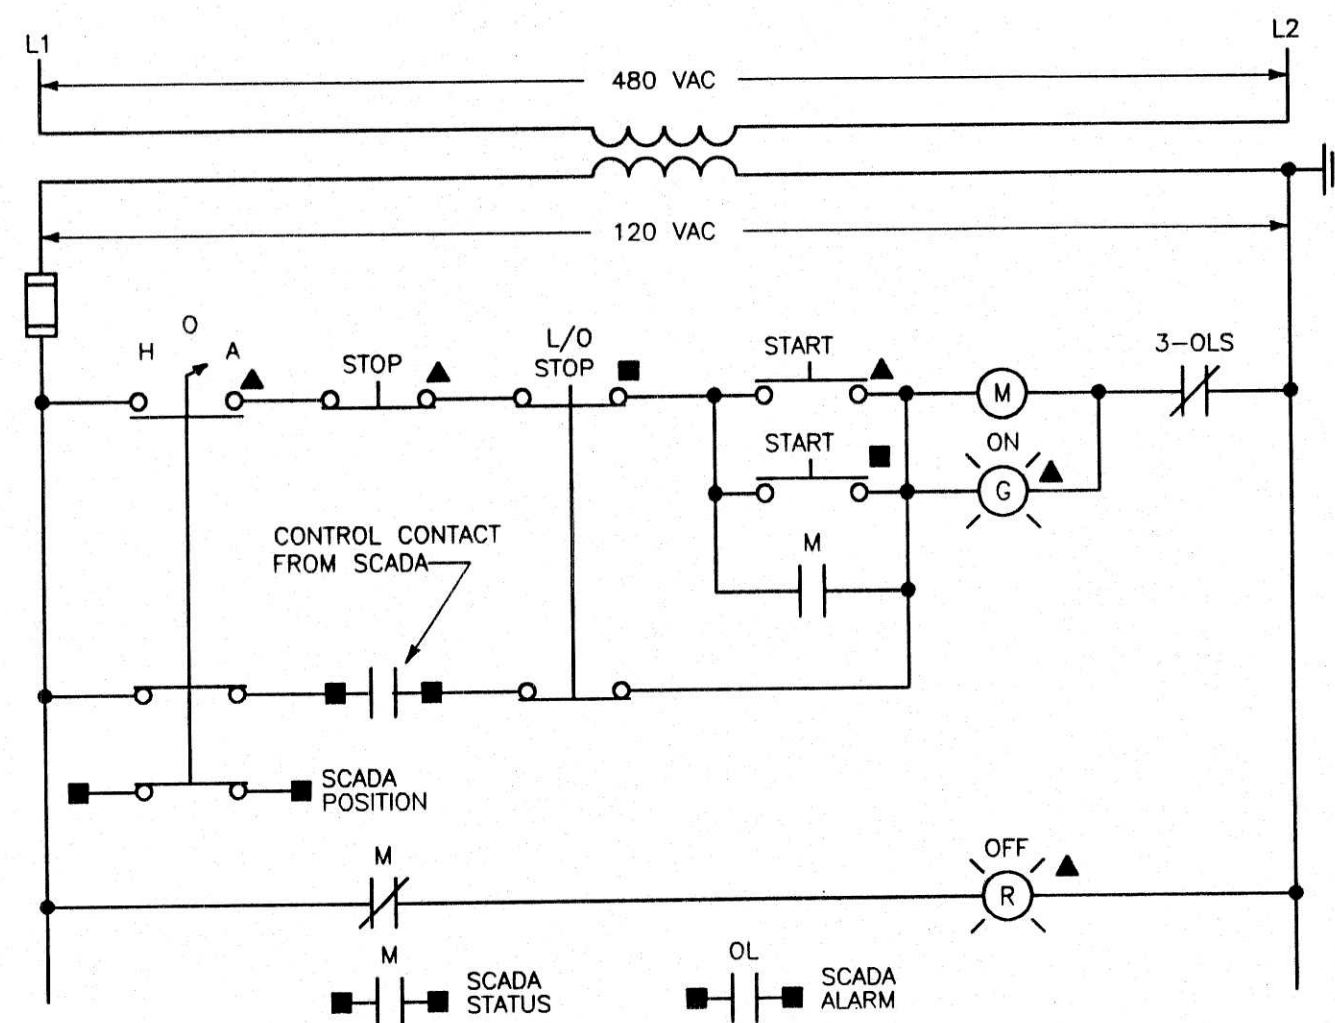


ELEMENTARY DIAGRAM NO. 1

GRIT CLASSIFIERS NO. 1 & 2 MCC-HW
 PEAK FLOW GRIT DRIVE MCC-HW
 PROCESS FLOW GRIT DRIVE MCC-HW
 BLOWERS NO. 1, 2 & 3 MCC-HW
 CONVEYOR MCC-HW
 PEAK FLOW WASHDOWN PUMP MCC-SW

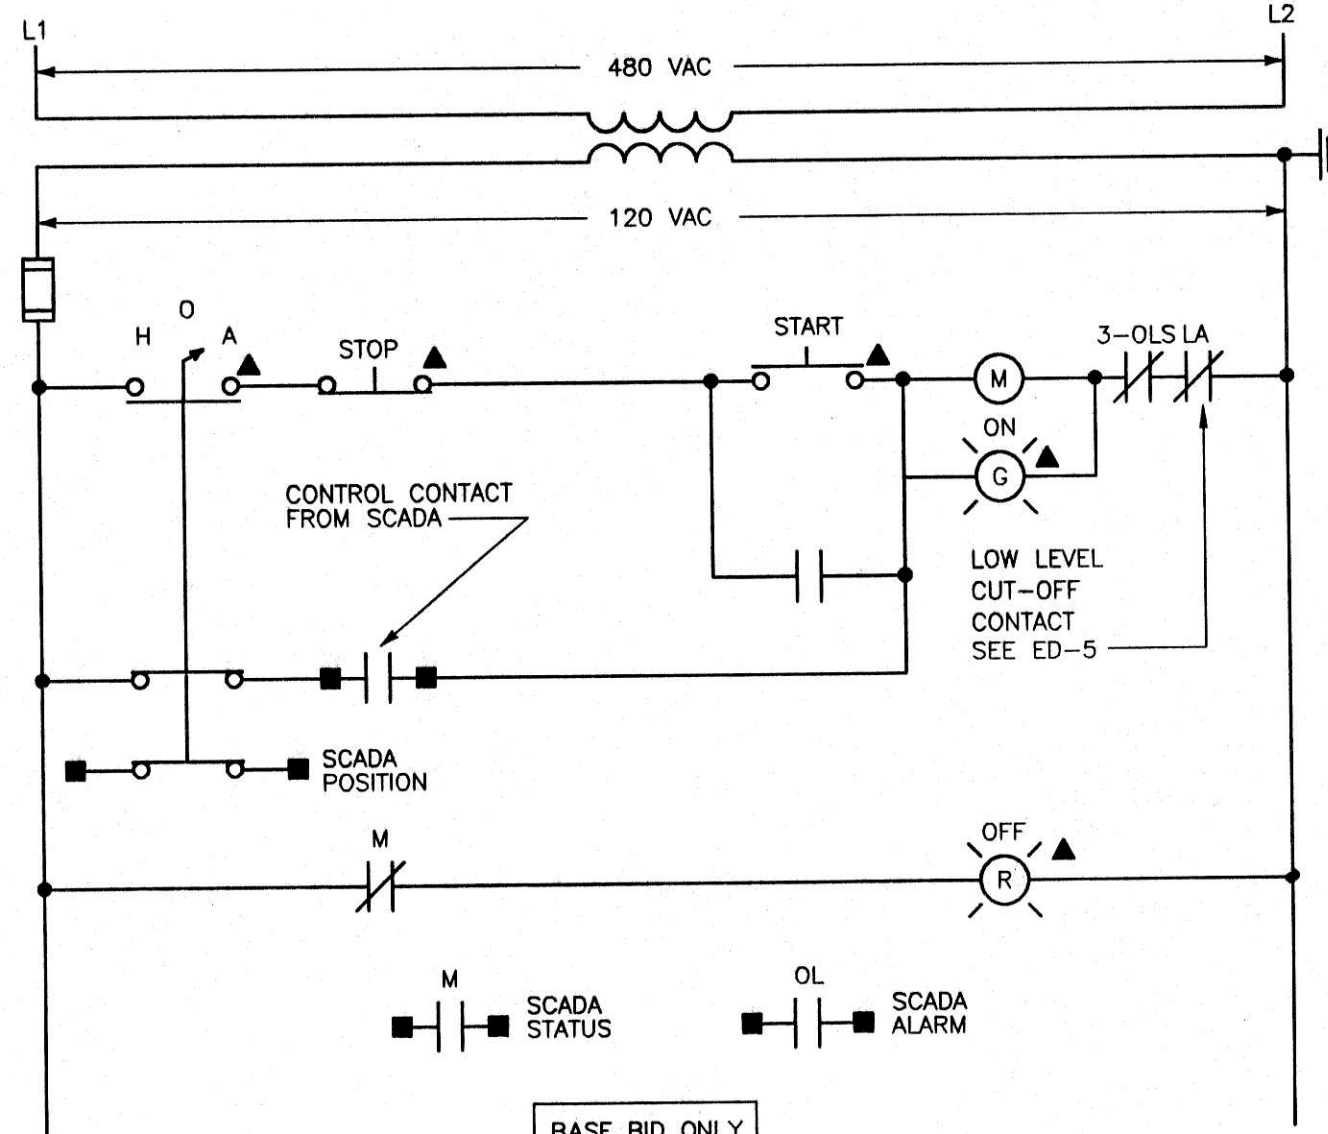


ELEMENTARY DIAGRAM NO. 2

AERATORS NO. 1-1 THRU 1-6 MCC-SW
 MIXERS NO. 1-1 THRU 1-2 MCC-SW

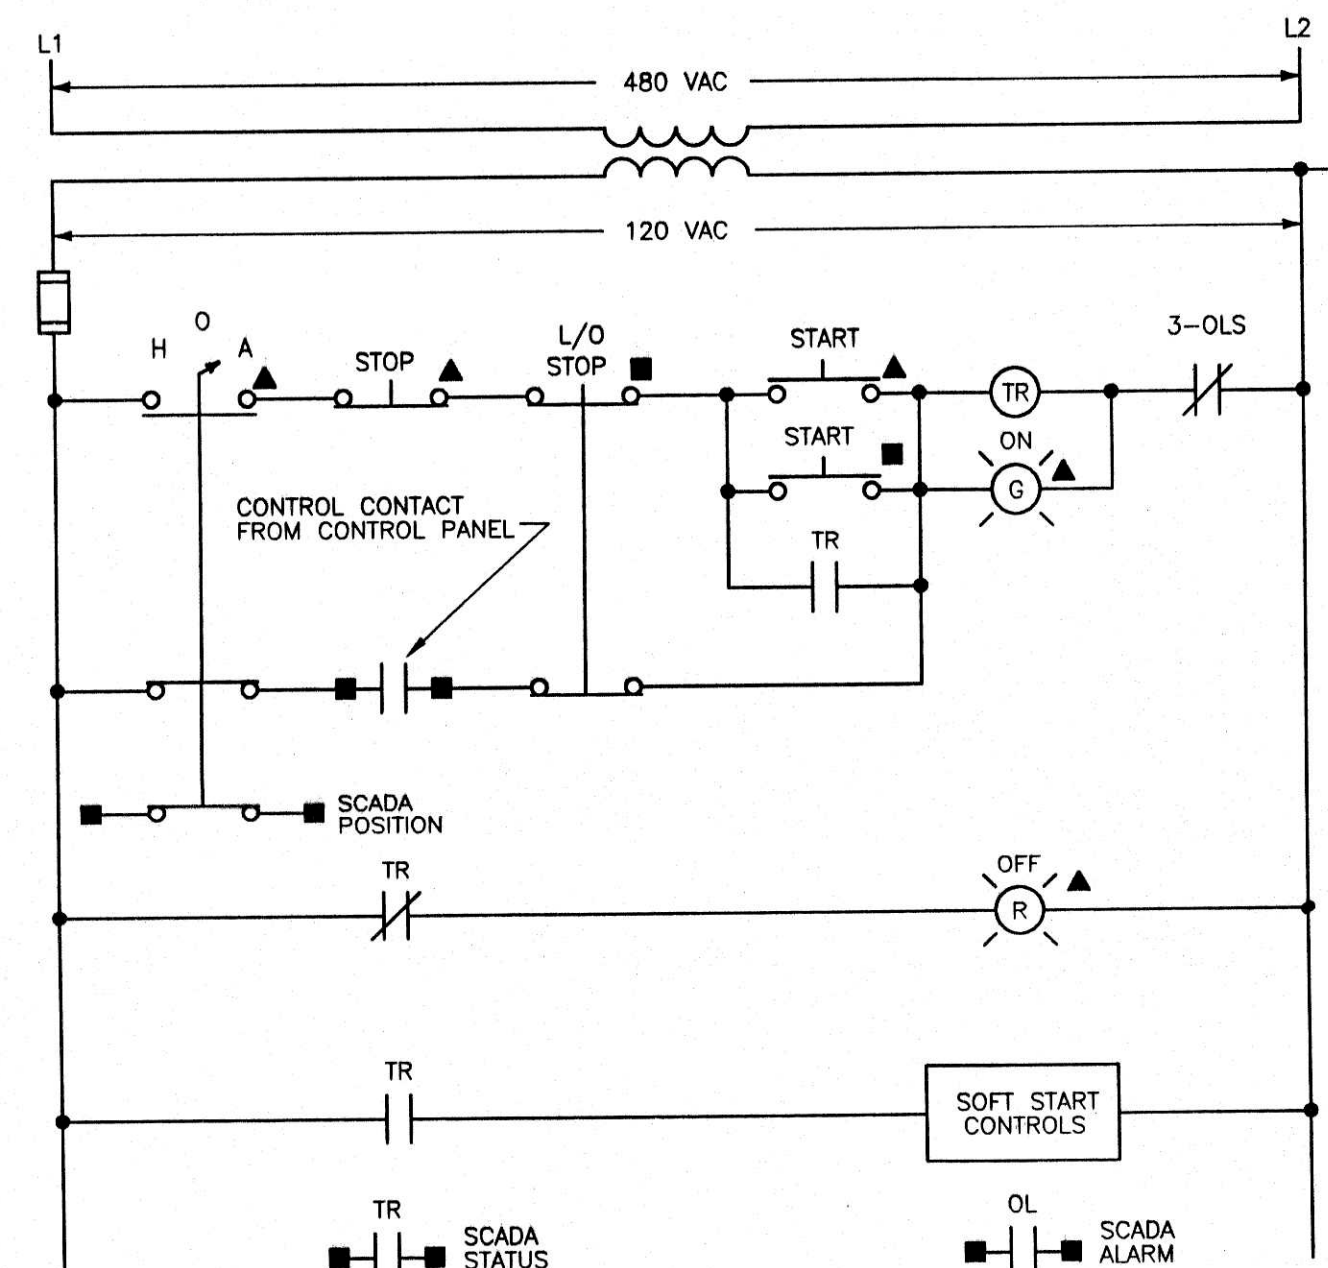


ELEMENTARY DIAGRAM NO. 4

PEAK FLOW PUMPS NO. 1, 2 & 3 MCC-SW

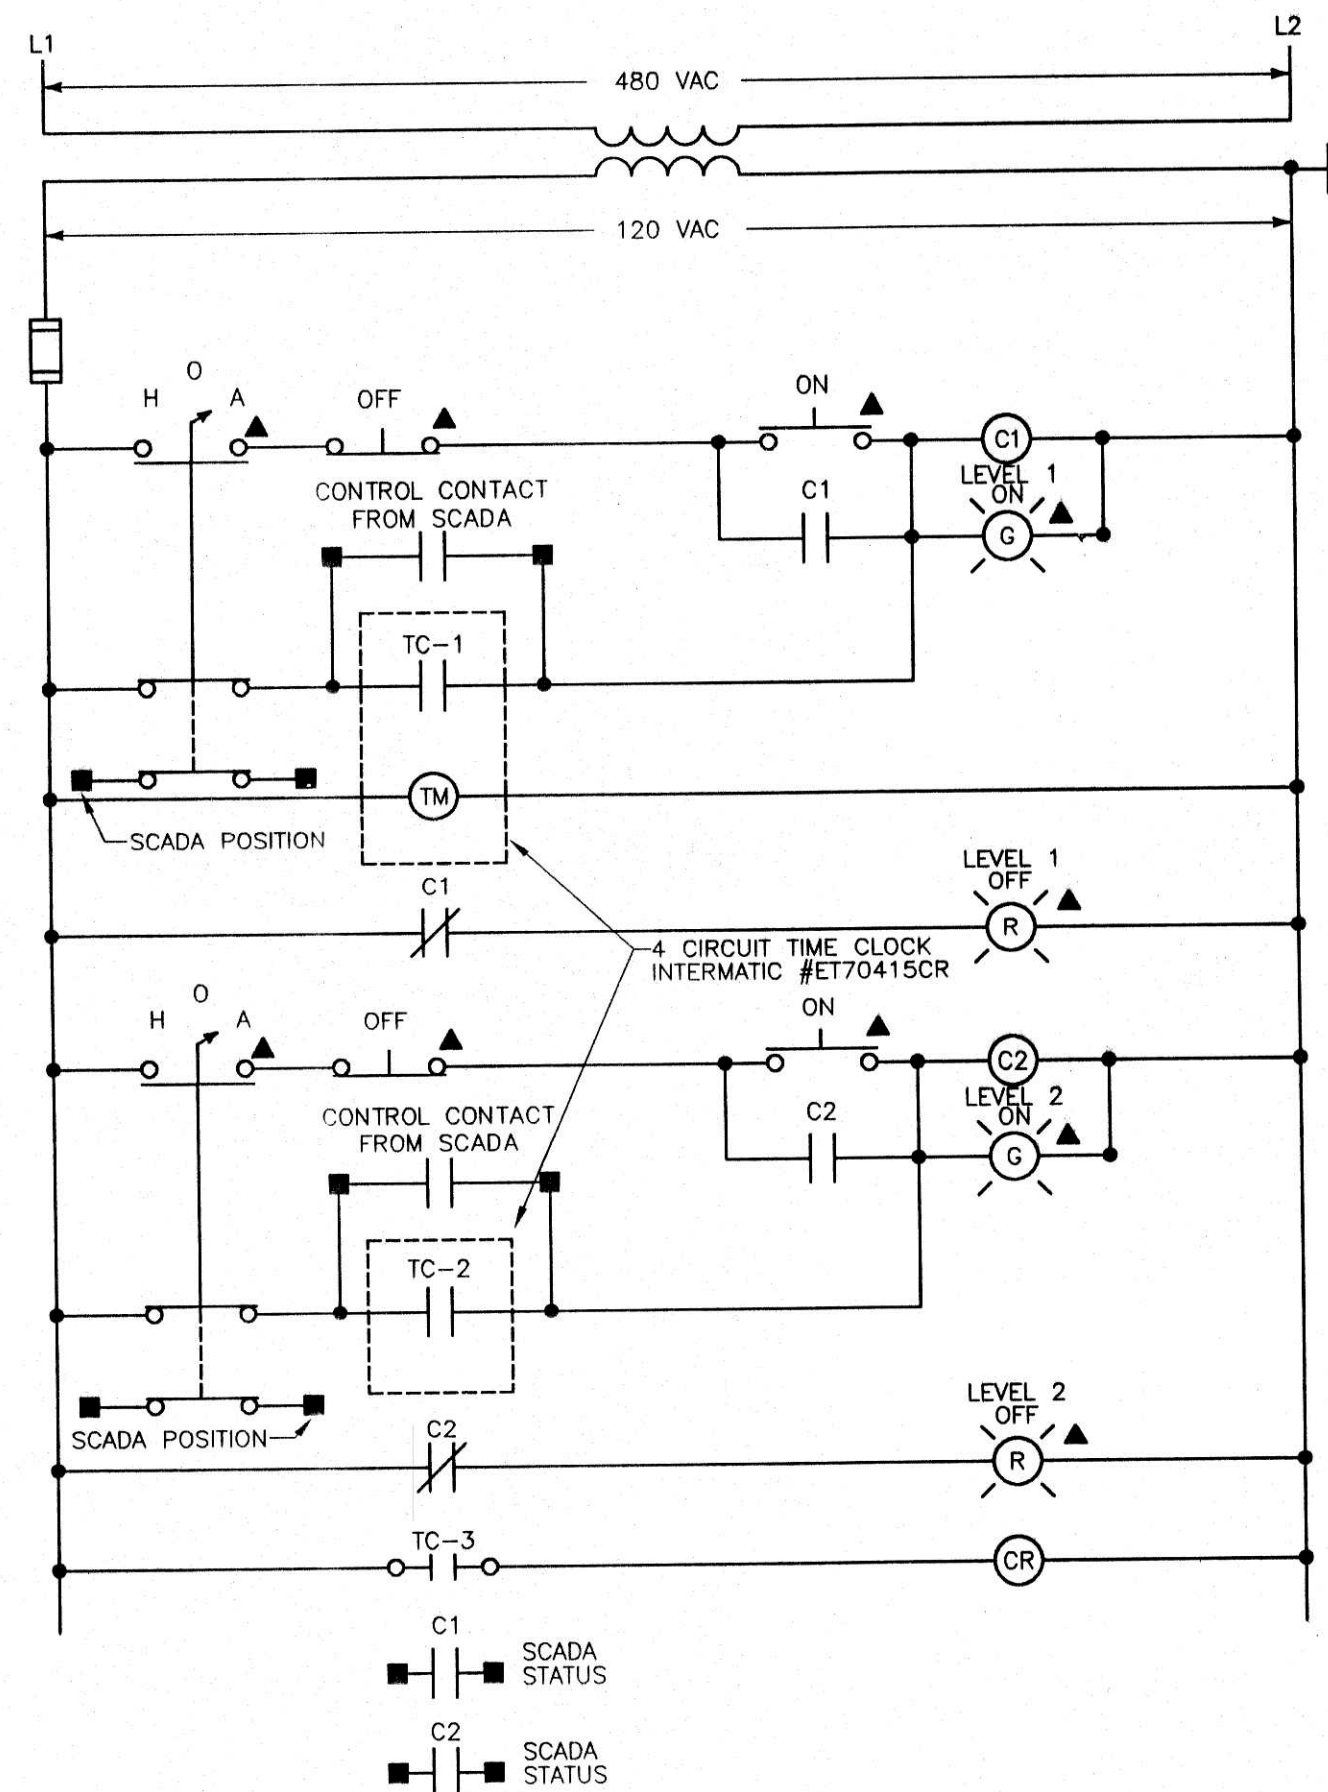


ELEMENTARY DIAGRAM NO. 6

HIGH MAST LIGHTING CONTROLS MCC-SW

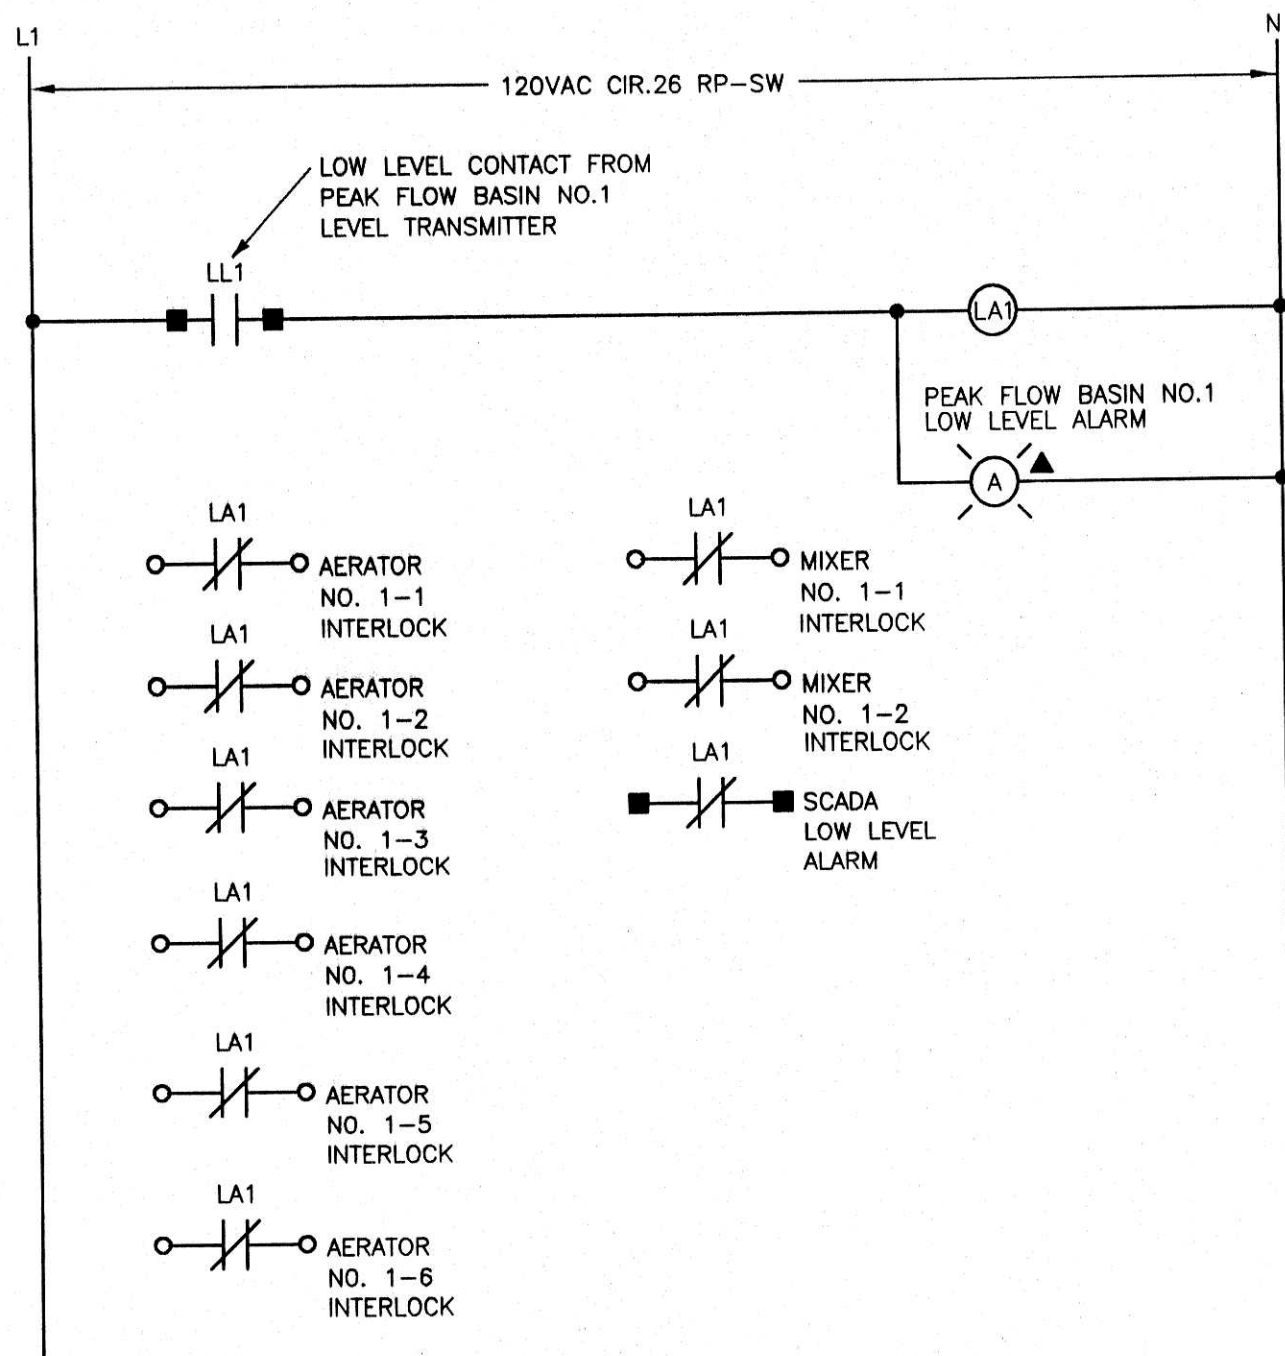


ELEMENTARY DIAGRAM NO. 5

PEAK FLOW BASIN LOW LEVEL CUT-OFF CONTROL MCC-SW

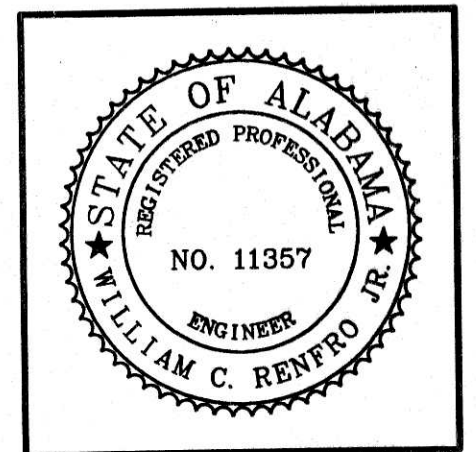

WATER WORKS & SEWER BOARD
 CITY OF ANNISTON
 CHOCOLOCOO WWTP
 IMPROVEMENTS
 ANNISTON, ALABAMA

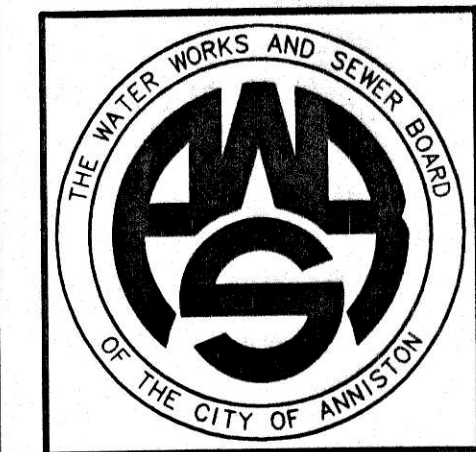

PROJECT NO.			98062		
DESIGNED			WCR		
DRAWN			CAB		
CHECKED			WCR		
APPROVED					
DATE			JULY 1999		
REVISIONS					
NO.		DATE		DESCRIPTION	
1		11-17-06		RECORD DRAWING	

RECORD
 DRAWING

ELEMENTARY DIAGRAMS

SHEET NO.
E1.03
 SEQUENCE 74 OF 84


JACKSON, RENFRO & ASSOC., INC.
 141 VILLAGE STREET • SUITE 1
 BIRMINGHAM, ALABAMA 35242
 JRA JOB NO. 99002

SCALE : NONE


MOTOR CONTROL CENTER SCHEDULE MCC—HW												
UNIT NO.	NAMEPLATE DESCRIPTION	MCC UNIT DESCRIPTION	ELECT. EQUIP. CHARACTERISTICS				STR. NEMA SIZE	AUX. DEVICES IN DOOR			REMARKS	
			HP	KW	V	Ø		PUSH BTNS.	SEL. SW.	IND. LTS.		
1A	SPACE	PROV. FOR FUTURE PLUG-IN UNIT			480	3						
1L	TVSS	250MV TVSS SEE SPECS.			480	3						
1P	MAIN BREAKER	400/3 BREAKER			277/480	3						
2A	SPACE	PROV. FOR FUTURE PLUG-IN UNIT			480	3						
2E	RP—HW	SEE PANEL SCHEDULE			120/208	3						
20	TRANSFORMER T—HW	DRY TYPE TRANSF. 480—120/208V—3Ø 4W W/ 20/3 PRI. BREAKER AND TAPS		15	480	3						
3A	SPACE	PROV. FOR FUTURE PLUG-IN UNIT			480	3						
3I	GRIT CLASSIFIER NO. 1	COMB. MAG. STR. FVNR W/ 3/3 MCP	3/4		460	3	1	2	1	2	SEE ELEMENTARY DIAGRAM NO. 1	
3M	GRIT CLASSIFIER NO. 2	COMB. MAG. STR. FVNR W/ 3/3 MCP	3/4		460	3	1	2	1	2	SEE ELEMENTARY DIAGRAM NO. 1	
3Q	PEAK FLOW FLOW GRIT DRIVE	COMB. MAG. STR. FVNR W/ 3/3 MCP	3/4		460	3	1	2	1	2	SEE ELEMENTARY DIAGRAM NO. 1	
3U	PROCESS FLOW GRIT DRIVE	COMB. MAG. STR. FVNR W/ 3/3 MCP	3/4		460	3	1	2	1	2	SEE ELEMENTARY DIAGRAM NO. 1	
4A	BLOWER NO. 1	COMB. MAG. STR. FVNR W/ 15/3 MCP	5		460	3	1	2	1	2	SEE ELEMENTARY DIAGRAM NO. 1	
4E	BLOWER NO. 2	COMB. MAG. STR. FVNR W/ 15/3 MCP	5		460	3	1	2	1	2	SEE ELEMENTARY DIAGRAM NO. 1	
4I	BLOWER NO. 3	COMB. MAG. STR. FVNR W/ 15/3 MCP	5		460	3	1	2	1	2	SEE ELEMENTARY DIAGRAM NO. 1	
4M	CONVEYOR	COMB. MAG. STR. FVNR W/ 7/3 MCP	3		460	3	1	2	1	2	SEE ELEMENTARY DIAGRAM NO. 1	
4Q	ODOR CONTROL SCRUBBER	200/3 BREAKER			460	3						
4U	PEAK FLOW WEIR GATE	15/3 BREAKER			460	3						
5A	AUGER MONSTER NO. 1	30/3 BREAKER	6.5		460	3						
5E	AUGER MONSTER NO. 2	30/3 BREAKER	6.5		460	3						
5I	SPACE	PROVISIONS FOR FUTURE PLUG-IN UNITS			480	3						

MOTOR CONTROL CENTER SCHEDULE MCC-SW												
UNIT NO.	NAMEPLATE DESCRIPTION	MCC UNIT DESCRIPTION	ELECT. EQUIP. CHARACTERISTICS				STR. NEMA SIZE	AUX. DEVICES IN DOOR			REMARKS	
			HP	KW	V	ø		PUSH BTNS.	SEL. SW.	IND. LTS.		
1A	MAIN LUGS	LUGS FOR CABLE SHOWN ON S/L DIAG.			277/480	3						
2A	HIGH MAST LIGHTING CONTROLS	TWO (2) 20A LIGHTING CONTACTORS W/ 20/3 BREAKER	9.9		480	3	2-20A	4	2	4	SEE ELEMENTARY DIAGRAM NO. 6	
2L	TVSS	250MV TVSS SEE SPECS			480	3						
2P	MCC-HW FEEDER	400/3 BREAKER			277/480	3						
3A	RP-SW	SEE PANEL SCHEDULE			120/208	3						
3R	SPACE	PROV. FOR FUTURE PLUG-IN UNITS			480	3						
4A	PEAK FLOW BASIN LOW LEVEL CUT-OFF CONTROLS	CONTROLS			120	1			1		SEE ELEMENTARY DIAGRAM NO. 5	
4I	GROUNDWATER PUMP STATION	20/3 BREAKER	5.4		460	3						
4M	TRANSFORMER T-SW	DRY TYPE TRANSF. 480-120/208V-3ø-4W W/ 60/3 PRI. BKR. & TAPS	45		480	3						
5A	AERATOR NO. 1-1	COMB. MAG. STR. FVNR W/ 30/3 MCP	15		460	3	2	2	1	2	SEE ELEMENTARY DIAGRAM NO. 2	
5E	AERATOR NO. 1-2	COMB. MAG. STR. FVNR W/ 30/3 MCP	15		460	3	2	2	1	2	SEE ELEMENTARY DIAGRAM NO. 2	
5I	AERATOR NO. 1-3	COMB. MAG. STR. FVNR W/ 30/3 MCP	15		460	3	2	2	1	2	SEE ELEMENTARY DIAGRAM NO. 2	
5M	AERATOR NO. 1-4	COMB. MAG. STR. FVNR W/ 30/3 MCP	15		460	3	2	2	1	2	SEE ELEMENTARY DIAGRAM NO. 2	
5Q	AERATOR NO. 1-5	COMB. MAG. STR. FVNR W/ 30/3 MCP	15		460	3	2	2	1	2	SEE ELEMENTARY DIAGRAM NO. 2	
5U	AERATOR NO. 1-6	COMB. MAG. STR. FVNR W/ 30/3 MCP	15		460	3	2	2	1	2	SEE ELEMENTARY DIAGRAM NO. 2	
6A	MIXER NO. 1-1	COMB. MAG. STR. FVNR W/ 15/3 MCP	7.5		460	3	1	2	1	2	SEE ELEMENTARY DIAGRAM NO. 2	
6E	MIXER NO. 1-2	COMB. MAG. STR. FVNR W/ 15/3 MCP	7.5		460	3	1	2	1	2	SEE ELEMENTARY DIAGRAM NO. 2	
6I	SPACE	PROV. FOR FUT. PLUG-IN UNITS			480	3						

MOTOR CONTROL CENTER SCHEDULE MCC-SW (CONTINUED)											
UNIT NO.	NAMEPLATE DESCRIPTION	MCC UNIT DESCRIPTION	ELECT. EQUIP. CHARACTERISTICS				STR. NEMA SIZE	AUX. DEVICES IN DOOR			REMARKS
			HP	KW	V	ø		PUSH BTNS.	SEL. SW.	IND. LTS.	
6M	PEAK FLOW WASHDOWN PUMP	COMB. MAG. STR. FVNR W/ 100/3 MCP	50		460	3	3	2	1	2	SEE ELEMENTARY DIAGRAM NO. 1
6S	SEWAGE SHREDDER	15/3 BREAKER			460	3					
7A	SLUICE GATE NO. 1-1	15/3 BREAKER			460	3					
7E	SLUICE GATE NO. 1-2	15/3 BREAKER			460	3					
7I	SLUICE GATE NO. 2-1	15/3 BREAKER			460	3					
7M	SLUICE GATE NO. 2-2	15/3 BREAKER			460	3					
7Q	SLUICE GATE NO. 3-1	15/3 BREAKER			460	3					
7U	SLUICE GATE NO. 3-2	15/3 BREAKER			460	3					
8A	SPACE	SPACE			460	3					
8E	EUH-1	20/3 BREAKER		10	480	3					
8I	EUH-2	20/3 BREAKER		10	480	3					
8M	EUH-3	20/3 BREAKER		10	480	3					
8Q	SPACE	PROV. FOR FUTURE PLUG-IN UNITS			480	3					
9A	PEAK FLOW PUMP NO. 1	COMB. MAG. SOFTSTART CONTROLLER W/ 300/3 BREAKER	150		460	3	C24	2	1	2	SEE ELEMENTARY DIAGRAM NO. 4
10A	PEAK FLOW PUMP NO. 2	COMB. MAG. SOFTSTART CONTROLLER W/ 300/3 BREAKER	150		460	3	C24	2	1	2	SEE ELEMENTARY DIAGRAM NO. 4
11A	PEAK FLOW PUMP NO. 3	COMB. MAG. SOFTSTART CONTROLLER W/ 300/3 BREAKER	150		460	3	C24	2	1	2	SEE ELEMENTARY DIAGRAM NO. 4

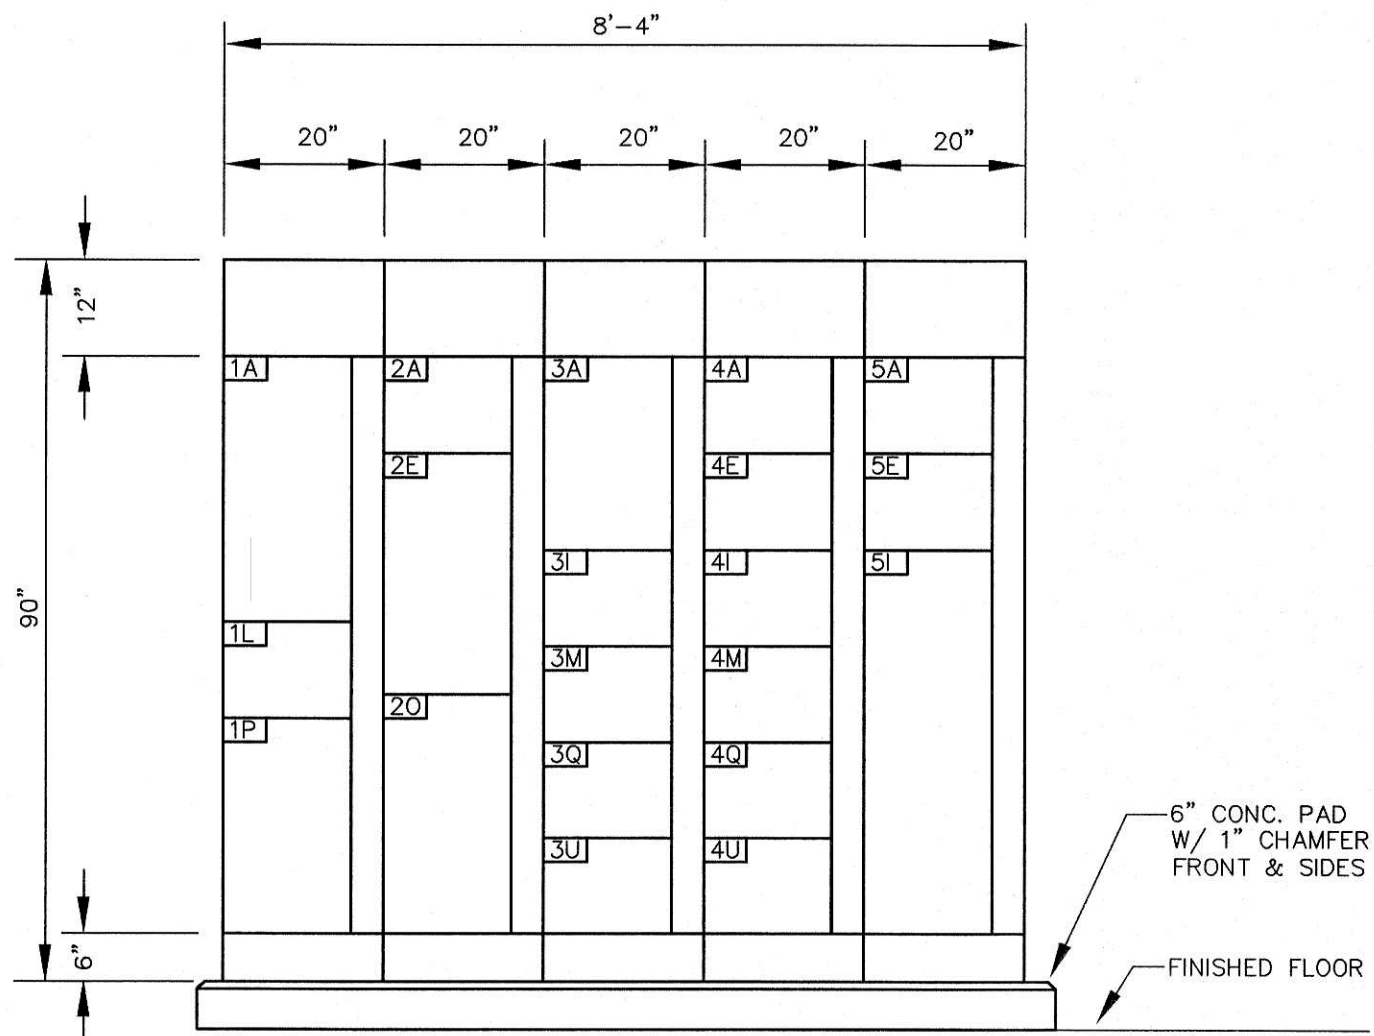


MCC-HW ELEVATION
SCALE : 1/2" = 1'-0"

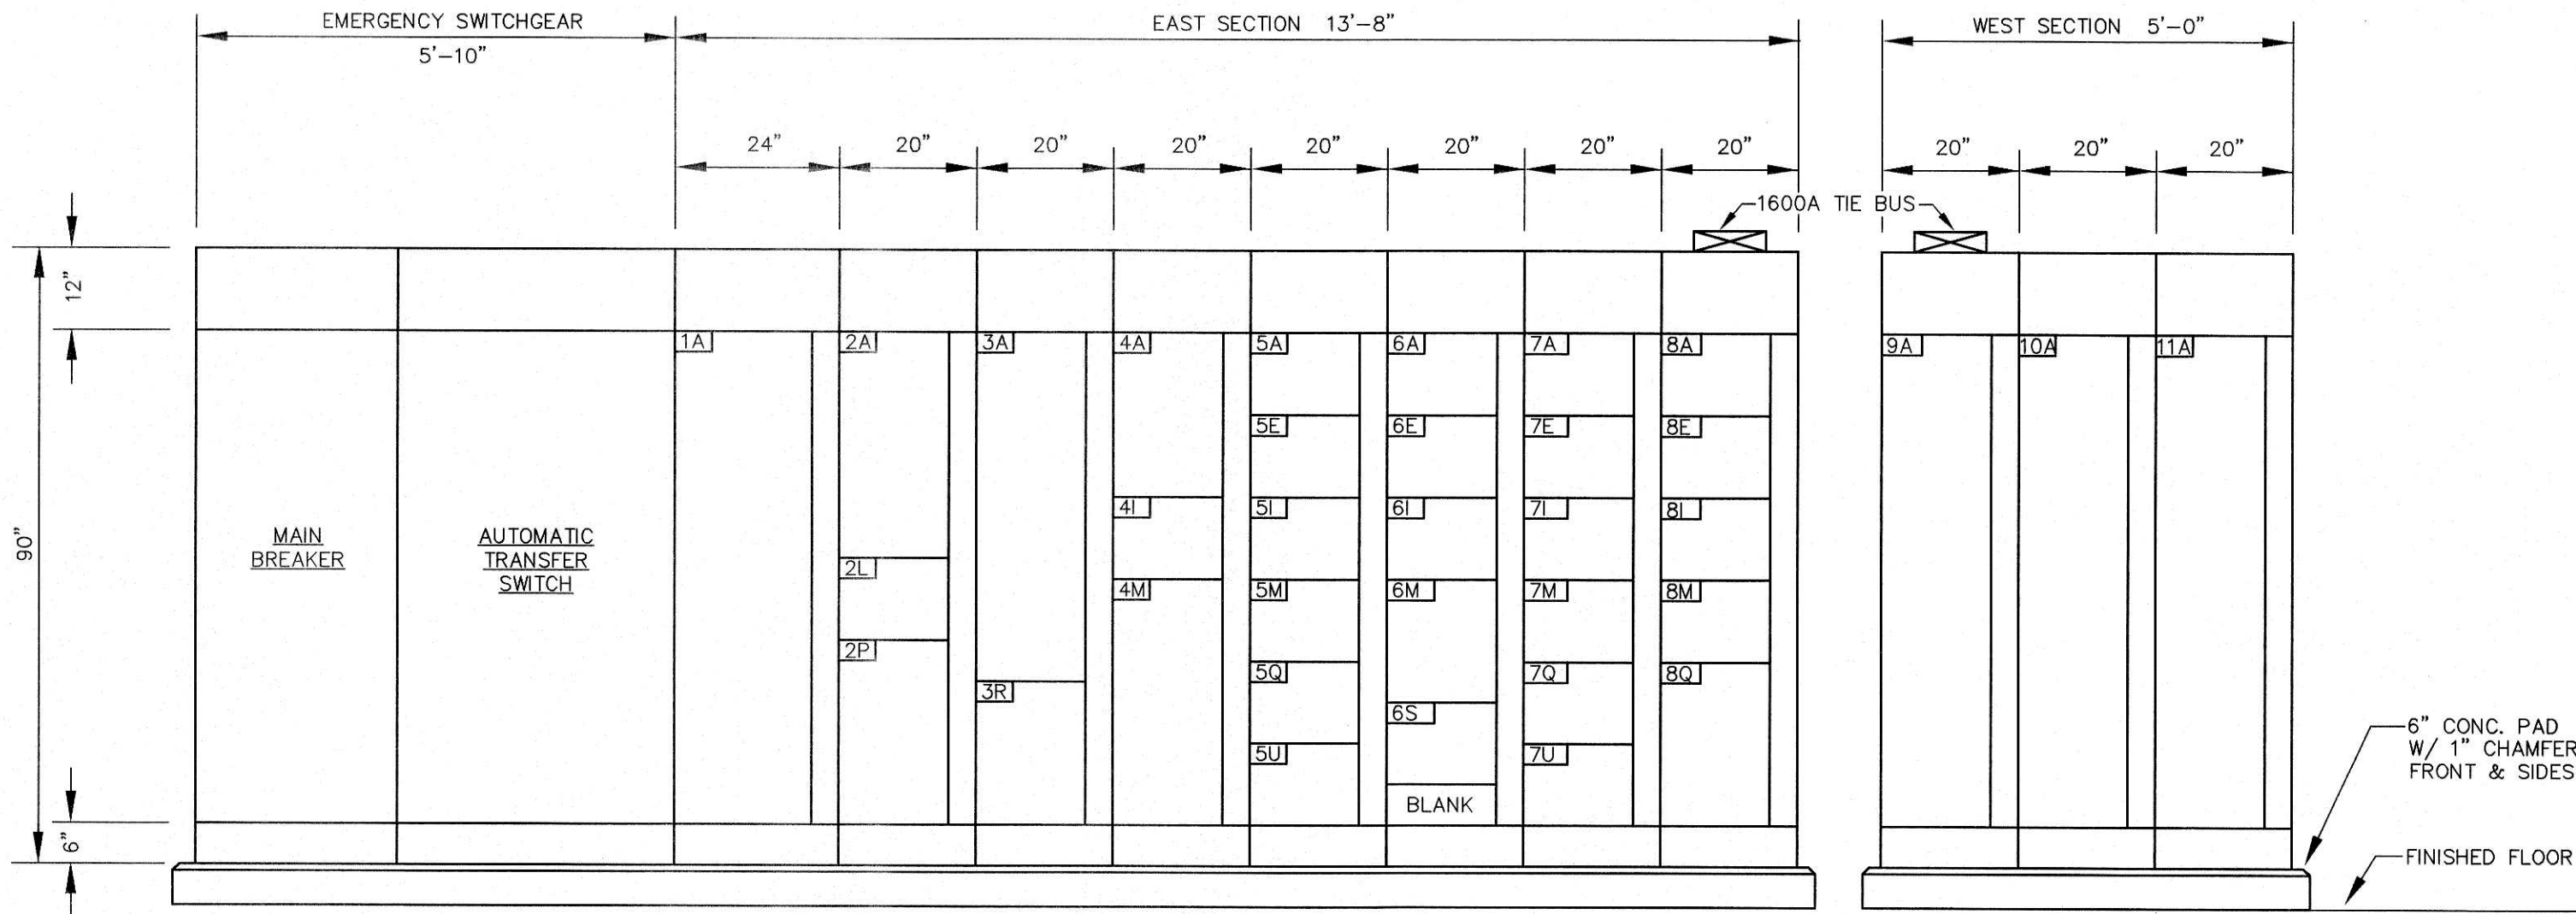


MCC-SW ELEVATION
SCALE : 1/2" = 1'-0"

JACKSON, RENFRO & ASSOC., INC.
141 VILLAGE STREET • SUITE 1
BIRMINGHAM, ALABAMA 35242
JRA JOB NO. 99002

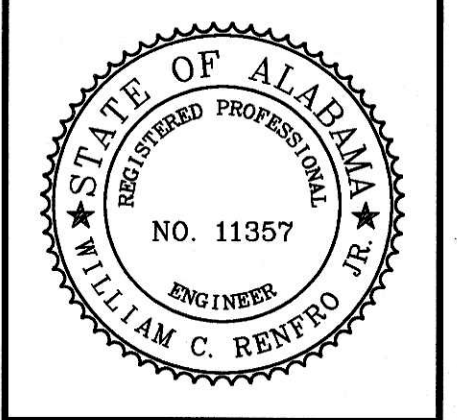

WATER WORKS & SEWER BOARD
CITY OF ANNISTON
CHOCOLOCO WWTP
IMPROVEMENTS
ANNISTON, ALABAMA

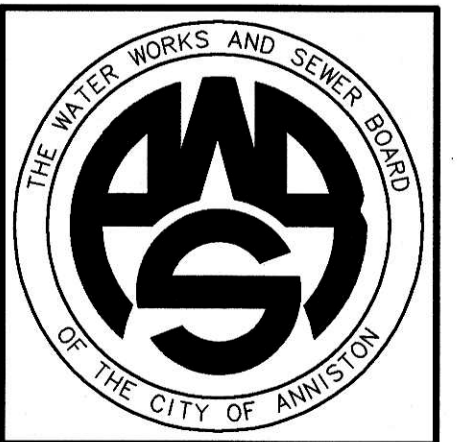


PROJECT NO.		98062
DESIGNED		WCR
DRAWN		CAB
CHECKED		WCR
APPROVED		
DATE		JULY 1999
REVISIONS		
N.O.	DATE	DESCRIPTION
1	11-17-06	RECORD DRAWING

RECORD
DRAWING

SHEET TITLE	MCC SCHEDULES & ELEVATIONS BASE BID
SHEET NO.	E1.02
SEQUENCE	73 OF 84

SCALE : NONE

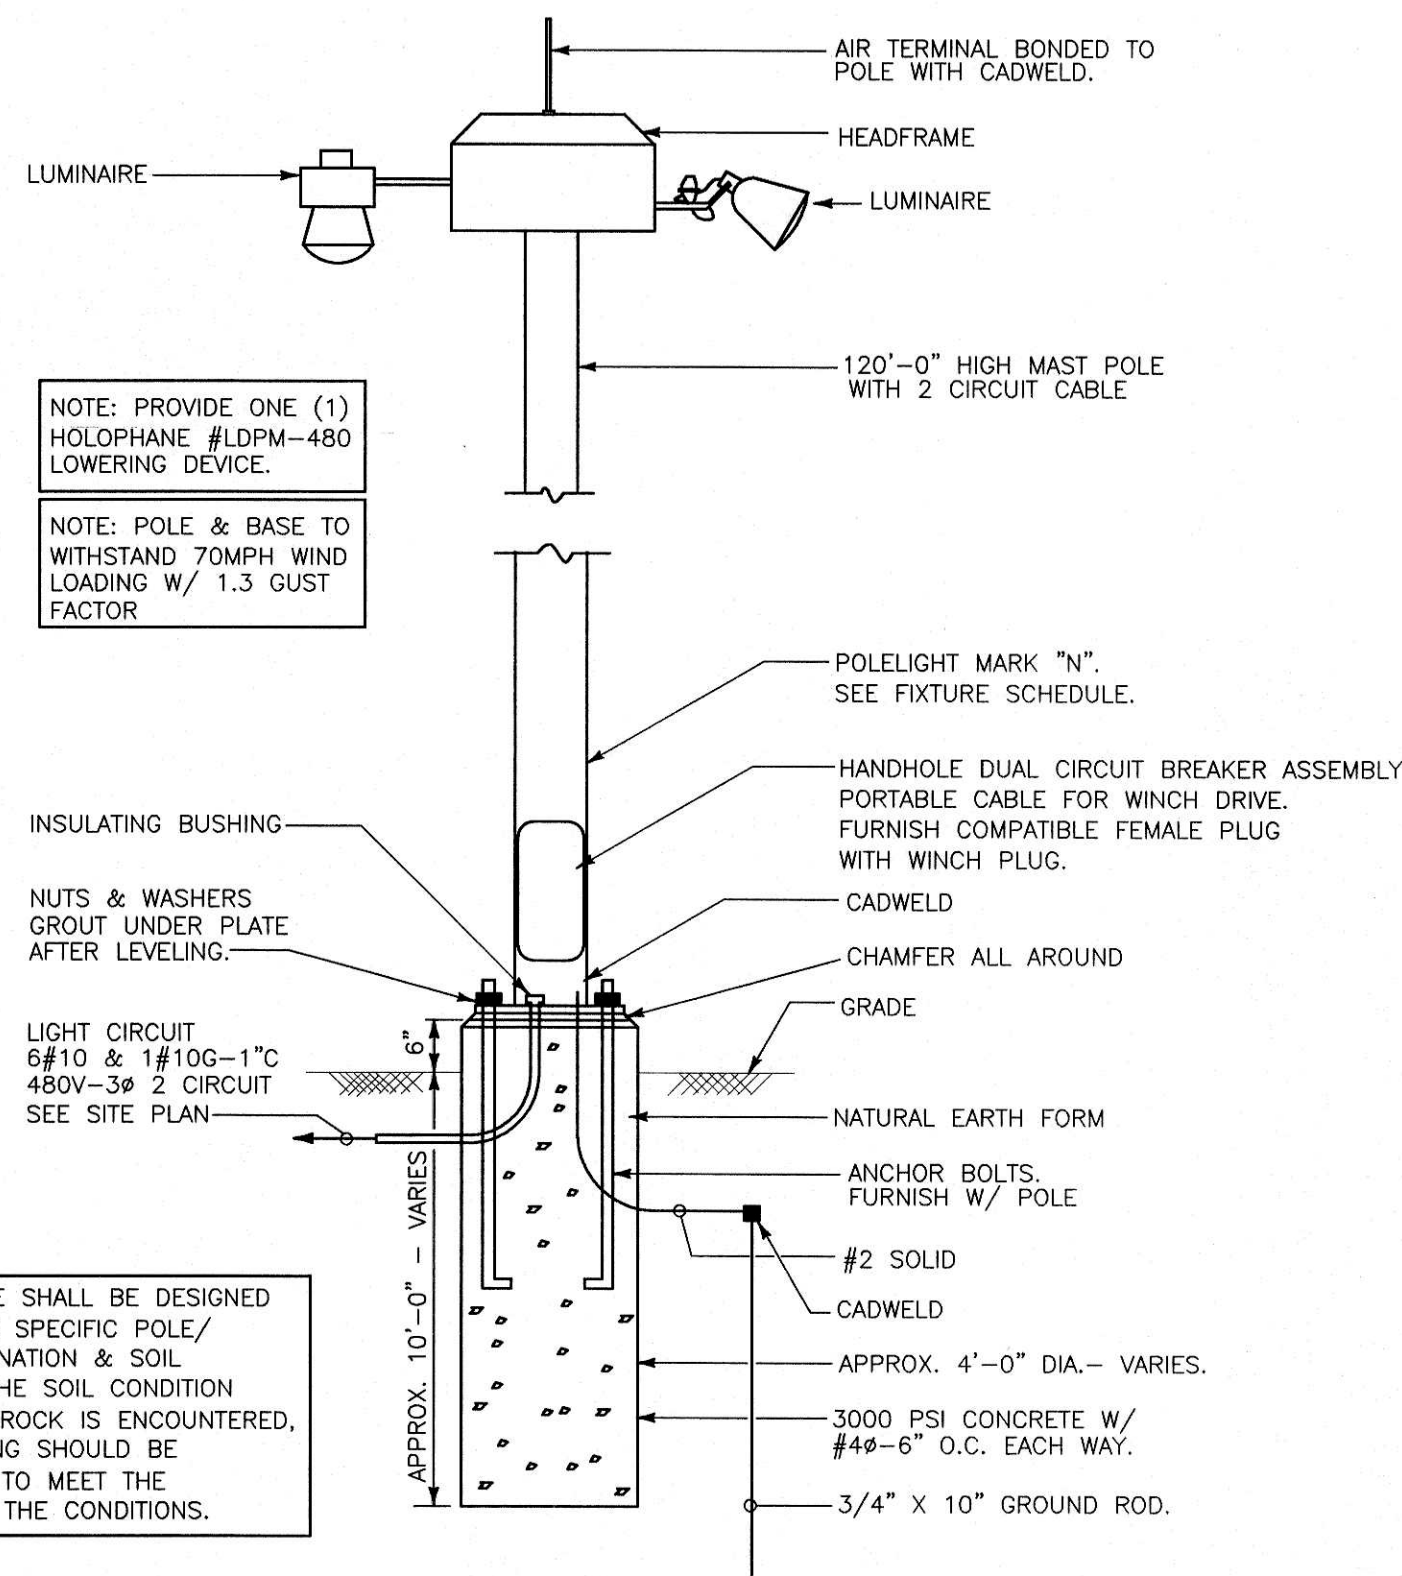

LIGHTING FIXTURE SCHEDULE						
MARK	FIXTURE MFG	CATALOG NO.	LAMPS			REMARKS
			NO. FIXT.	WATTS /TYPE	MOUNTING HEIGHT	
B	LITHONIA	DMW-240-AR-GEB	2	34	RSCW	CEILING
EM	LITHONIA	ELU2X	FURNISHED WITH FIXTURE		8'-0" AFF	OUTLET BOX
G	BEGA	2984MH-BL	1	100	MH	SEE ARCH. DRAWINGS
L	LITHONIA	DMW-240-AR-GEB	2	34	RSCW	AS DIRECTED
N	HOLOPHANE	HMS-120-GALV-9-LD5-3-(3) HMSTC10HP48A1 (6)PB2C10HP4833-SS-LA-LR 2 CIRCUIT	9	1000	CLEAR HPS	120'-0" POLE SEE DETAIL E1.01
X2	LITHONIA	LES1GELN	FURNISHED WITH FIXTURE		ABOVE DOOR	OUTLET BOX

18 LIGHTING FIXTURE SCHEDULE

SCALE : NONE


GENERAL ELECTRICAL NOTES	
1.	SPECIAL ATTENTION IS CALLED TO THE FACT THAT THIS IS AN OPERATING FACILITY AND AS SUCH NO DISRUPTION TO POWER, CONTROL OR PROCESS EQUIPMENT SHALL BE MADE WITHOUT PRIOR WRITTEN AUTHORIZATION FROM THE PLANT OPERATOR. ALL OUTAGES SHALL BE SCHEDULED THROUGH AND COORDINATED WITH THE PLANT OPERATOR.
2.	REMOVE ALL EXISTING ELECTRICAL EQUIPMENT AND WIRING MADE OBSOLETE BY THIS RENOVATION AND DISPOSE OF AS DIRECTED BY THE ENGINEER.
3.	EXISTING PANEL DIRECTORY CARDS MODIFIED BY THIS RENOVATION SHALL BE RETYPED TO INDICATE CONNECTED CIRCUITS.
4.	THIS CONTRACTOR SHALL FURNISH ALL MATERIALS AND LABOR NECESSARY TO EXTEND CIRCUITS AND MAKE RECONNECTIONS TO ANY ACTIVE ELECTRICAL DEVICES ON WHICH THE BRANCH CIRCUIT IS INTERRUPTED BY THIS ALTERATION. CARE SHALL BE TAKEN TO INSURE THAT EXISTING PANEL AND FEEDER RATINGS ARE NOT EXCEEDED.
5.	DEVICE PLATES SHALL BE TYPE 302 STAINLESS STEEL AS MANUFACTURED BY HUBBELL, SIERRA OR APPROVED EQUAL.
6.	ALL EQUIPMENT SHALL BE GROUNDED AND BONDED IN ACCORDANCE WITH NEC.
7.	CONTRACTOR SHALL VISIT THE SITE OF THE WORK PRIOR TO SUBMITTING BID TO EXAMINE CAREFULLY LOCAL CONDITIONS AND DIFFICULTIES TO BE ENCOUNTERED. ANY DISCREPANCY BETWEEN PLANS AND EXISTING CONDITIONS SHALL IMMEDIATELY BE CALLED TO THE ATTENTION OF THE ENGINEER.
8.	THIS CONTRACTOR SHALL VERIFY EXACT REQUIREMENTS FOR ALL MECHANICAL EQUIPMENT FROM MANUFACTURER'S RECOMMENDATIONS PRIOR TO ROUGHING IN CONDUIT AND SHALL ADJUST CONDUIT SIZE, WIRE SIZE AND CIRCUIT PROTECTION SIZE ACCORDINGLY. IF REQUIREMENTS ARE LARGER THAN CALLED FOR ON ELECTRICAL PLANS NOTIFY ENGINEER IMMEDIATELY.
9.	CONTRACTOR SHALL VERIFY ALL REQUIREMENTS FOR POWER SERVICE WITH UTILITY COMPANY PRIOR TO SUBMITTING BID. IF THEIR REQUIREMENTS ARE AT A VARIANCE WITH THOSE SHOWN ON PLANS THE CONTRACTOR SHALL INFORM ENGINEER IMMEDIATELY. ALL COSTS INCURRED WITH THE UTILITY COMPANY FOR SERVICE SHALL BE INCLUDED IN BID PRICE. IF SUCH COSTS ARE NOT AVAILABLE AT BID TIME CONTRACTOR SHALL INCLUDE WITH BID A LETTER FROM A RESPONSIBLE PARTY WITH THE UTILITY COMPANY STATING SUCH, AND COSTS WILL THEN BE EXCLUDED FROM THE BID PRICE.

13 GENERAL ELECTRICAL NOTES

SCALE : NONE

15 FIXTURE MARK "N" POLE DETAIL

SCALE : NONE

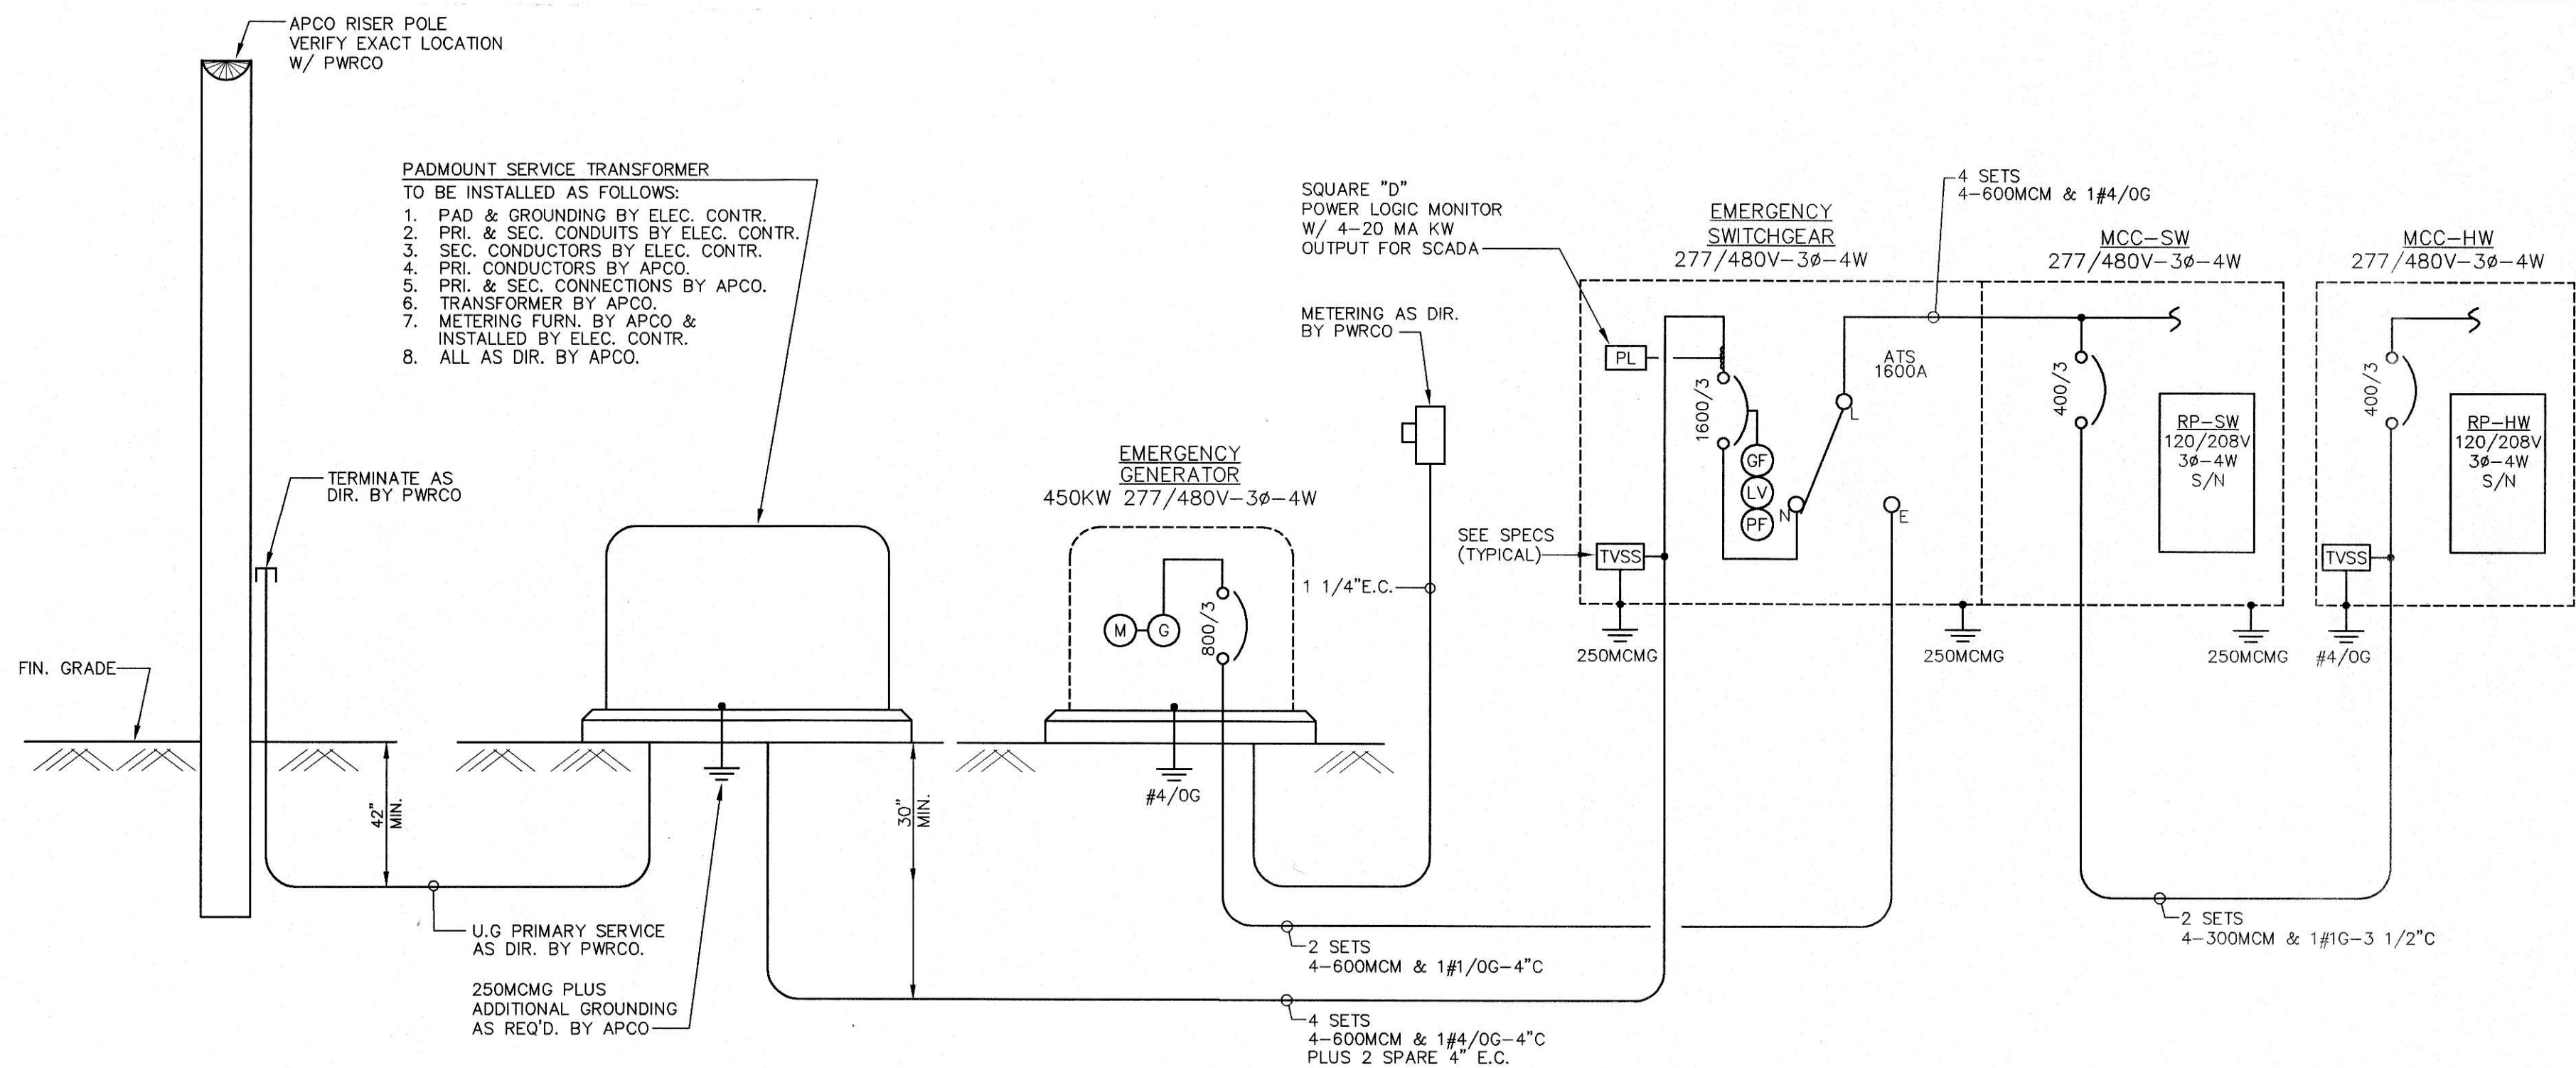

05 SINGLE LINE DIAGRAM

SCALE : NONE

GENERAL ELECTRICAL LEGEND

(A)	FIXTURE OUTLET - CEILING - SURFACE OR PENDANT MOUNTED - INCANDESCENT OR H.I.D. - FIXTURE MARK "A", CIRCUIT NO.2 (TYP.).
(B)	FIXTURE OUTLET - CEILING - RECESSED - INCANDESCENT OR H.I.D..
(C)	FIXTURE OUTLET - CEILING - SURFACE OR PENDANT MOUNTED - FLUORESCENT.
(D)	FIXTURE OUTLET - CEILING - RECESSED - FLUORESCENT.
(E)	FIXTURE OUTLET - WALL - BRACKET MOUNTED - INCANDESCENT OR H.I.D..
(F)	FIXTURE OUTLET - WALL - BRACKET MOUNTED - FLUORESCENT.
(G)	FIXTURE OUTLET - EXIT LIGHT - DIRECTIONAL ARROWS AS INDICATED.
(H)	WALL OUTLET - DUPLEX - 15A - 125V - 2P - 3W - GROUNDING - HUBBELL 5262.
(I)	WALL OUTLET - DUPLEX - 15A - 125V - 2P - 3W - GROUNDING - "GFI" TYPE WEATHERPROOF - BRYANT GF-R-52FT WITH WEATHERPROOF PLATE.
(J)	WALL OUTLET - DUPLEX - 20A - 125V - 2P - 3W - GROUNDING - HUBBELL 5362.
(K)	WALL OUTLET - DUPLEX - 20A - 125V - 2P - 3W - GROUNDING - DRINKING FOUNTAIN OUTLET - HUBBELL 5362 - EXACT MOUNTING HEIGHT AS DIRECTED BY EQUIPMENT SUPPLIER.
(L)	WALL OUTLET - DUPLEX - 15A - 125V - 2P - 3W - GROUNDING - "GFI" TYPE - BRYANT GF-R-52FT.
(M)	WALL OUTLET - DUPLEX - 20A - 125V-2P-3W - GROUNDING - CORROSION RESISTANT HUBBELL 530MB2 WITH PLASTIC PLATE.
(N)	FLOOR OUTLET - CONDUIT STUB UP.
(O)	FLOOR OUTLET - JUNCTION BOX - CROUSE HINDS "FS" TYPE CAST BOX.
(P)	WALL OUTLET - JUNCTION BOX - FLUSH MOUNTED.
(Q)	CEILING OUTLET - JUNCTION BOX.
(R)	BRANCH CIRCUIT - CONCEALED IN WALLS OR CEILING.
(S)	BRANCH CIRCUIT - EXPOSED ON WALLS OR CEILING.
(T)	BRANCH CIRCUIT - CONCEALED IN FLOOR SLAB OR DIRT FILL.
(U)	BRANCH CIRCUIT - HOMERUN - 2 NO.12, 3 NO.12, ETC. - WITH GREEN INSULATED GROUND WIRE SIZED PER NEC TABLE 250-95 - 3/4" MINIMUM.
(V)	BRANCH CIRCUIT - HOMERUN - 2 NO.10, 3 NO.10, ETC. - MAY BE USED WITH OTHER WIRE SIZES - WITH GREEN INSULATED GROUND WIRE SIZED PER NEC TABLE 250-95 - 3/4" MINIMUM.
(W)	FLEXIBLE CONNECTION TO EQUIPMENT.
(X)	SWITCH OUTLET - S.P.S.T. - 15A - 120-277VAC - HUBBELL 1201.
(Y)	SWITCH OUTLET - 3 WAY - 15A - 120-277VAC - HUBBELL 1203.
(Z)	SWITCH OUTLET - 4 WAY - 15A - 120-277VAC - HUBBELL 1204.
(AA)	SWITCH OUTLET - CONTROLS OUTLET "a", ETC.
(AB)	SWITCH OUTLET - MANUAL MOTOR STARTER - TOGGLE TYPE - 2 POLE - SQUARE "D" TYPE KS-1.
(AC)	SWITCH OUTLET - MOMENTARY S.P.D.T. - 15A - 120-277VAC - HUBBELL 1556.
(AD)	DISTRIBUTION CENTER.
(AE)	TRANSFORMER - POWER.
(AF)	MAGNETIC MOTOR STARTER.
(AG)	DISCONNECT SWITCH - FUSED.
(AH)	DISCONNECT SWITCH - NONFUSED.
(AI)	DISCONNECT SWITCH - NONFUSED - CORROSION RESISTANT.
(AJ)	MOTOR OUTLET - SIZE AS SHOWN.
(AK)	UNIT HEATER - ELECTRICAL - ARROW INDICATES DIRECTION.
(AL)	ELECTRIC DUCT HEATER.
(AM)	FLOAT SWITCH.
(AN)	PUSHBUTTON STATION - NUMBER OF BUTTONS AS SHOWN.
(AO)	PULL BOX - POWER AND INSTRUMENTATION - SEE DETAIL E1.05-05.
(AP)	POWER AND INSTRUMENTATION DUCT BANK - SEE DETAIL E1.05-14 & 17.
(AQ)	INSTRUMENTATION WIRING - IN RIGID STEEL CONDUIT.
(AR)	LEVEL TRANSMITTER.
(AS)	FLOW TRANSMITTER.
(AT)	ULTRASONIC TRANSPONDER.
(AU)	SWITCH OUTLET - PILOT LIGHT - S.P.S.T. - 15A - 120-277VAC - ON WHEN SWITCH IS ON - HUBBELL 1201-PLC.
(AV)	SOLENOID VALVE.
(AW)	GROUND ROD - 3/4" X 10'-0" COPPER CLAD.
(AX)	TRANSIENT VOLTAGE SURGE SUPPRESSION - SEE SPECS.
(AY)	MOTORIZED VALVE ACTIVATOR.
(AZ)	UNDERGROUND PRIMARY IN CONDUIT.
(BA)	PHOTOELECTRIC CONTROL S.P.S.T. - 120VAC - 2000W - TORK 2101 - MOUNT ON ROOF FACING NORTH.

06 GENERAL ELECTRICAL LEGEND


SCALE : NONE

PANEL SCHEDULE								
MARK	TYPE	MAINS		BRANCH BREAKERS				REMARKS
		TYPE	AMPS	1-POLE	2-POLE	3-POLE	SPACES	
RP-SW	SQUARE "D" NQOB	150A MB	225	120/208V 3#-4W S/N	30-20A		6-20-1	MCC-SW
RP-HW	GE-AQ	50A MB	100	120/208V 3#-4W S/N	15-20A 1-20A*		6-20-1	MCC-HW


JACKSON, RENFRO & ASSOC., INC.
141 VILLAGE STREET • SUITE 1
BIRMINGHAM, ALABAMA 35242
JRA JOB NO. 99002

01 PANEL SCHEDULE

SCALE : NONE

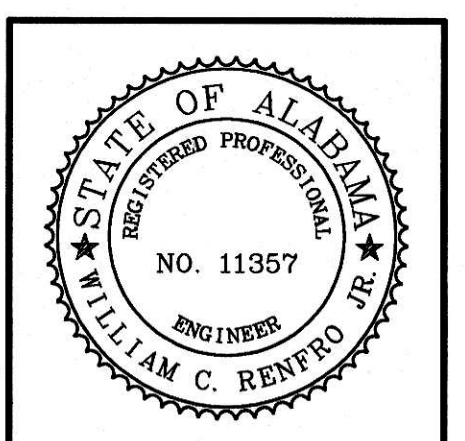

WATER WORKS & SEWER BOARD
CITY OF ANNISTON
CHOCOLOCCO WWTP
IMPROVEMENTS
ANNISTON, ALABAMA

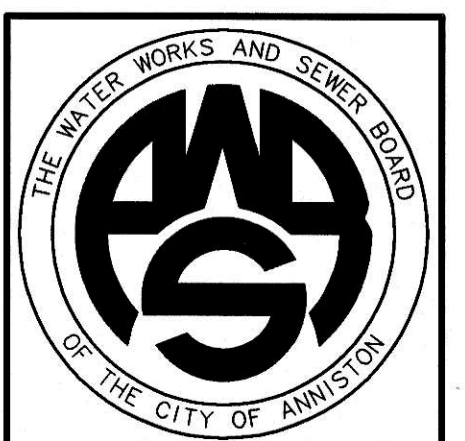

PROJECT NO.		98062
DESIGNED		WCR
DRAWN		CAB
CHECKED		WCR
APPROVED		
DATE		JULY 1999
REVISIONS		
NO.	DATE	DESCRIPTION
1	11-17-06	RECORD DRAWING

RECORD
DRAWING

ELECTRICAL
LEGEND, NOTES,
SCHEDULES AND
S/L DIAGRAM

SHEET NO.
E1.01
SEQUENCE 72 OF 84